

TOWN OF CLAYPOOL


KOSCIUSKO COUNTY, INDIANA

CONTRACT C - STORM SEWER IMPROVEMENTS


DECEMBER 2024

TOWN COUNCIL

BEN STAGE, JR.	PRESIDENT
DON MILLER	MEMBER
EUGENE WARNER	MEMBER
PAT WARNER	CLERK-TREASURER
RAMA SOBHANI	ATTORNEY

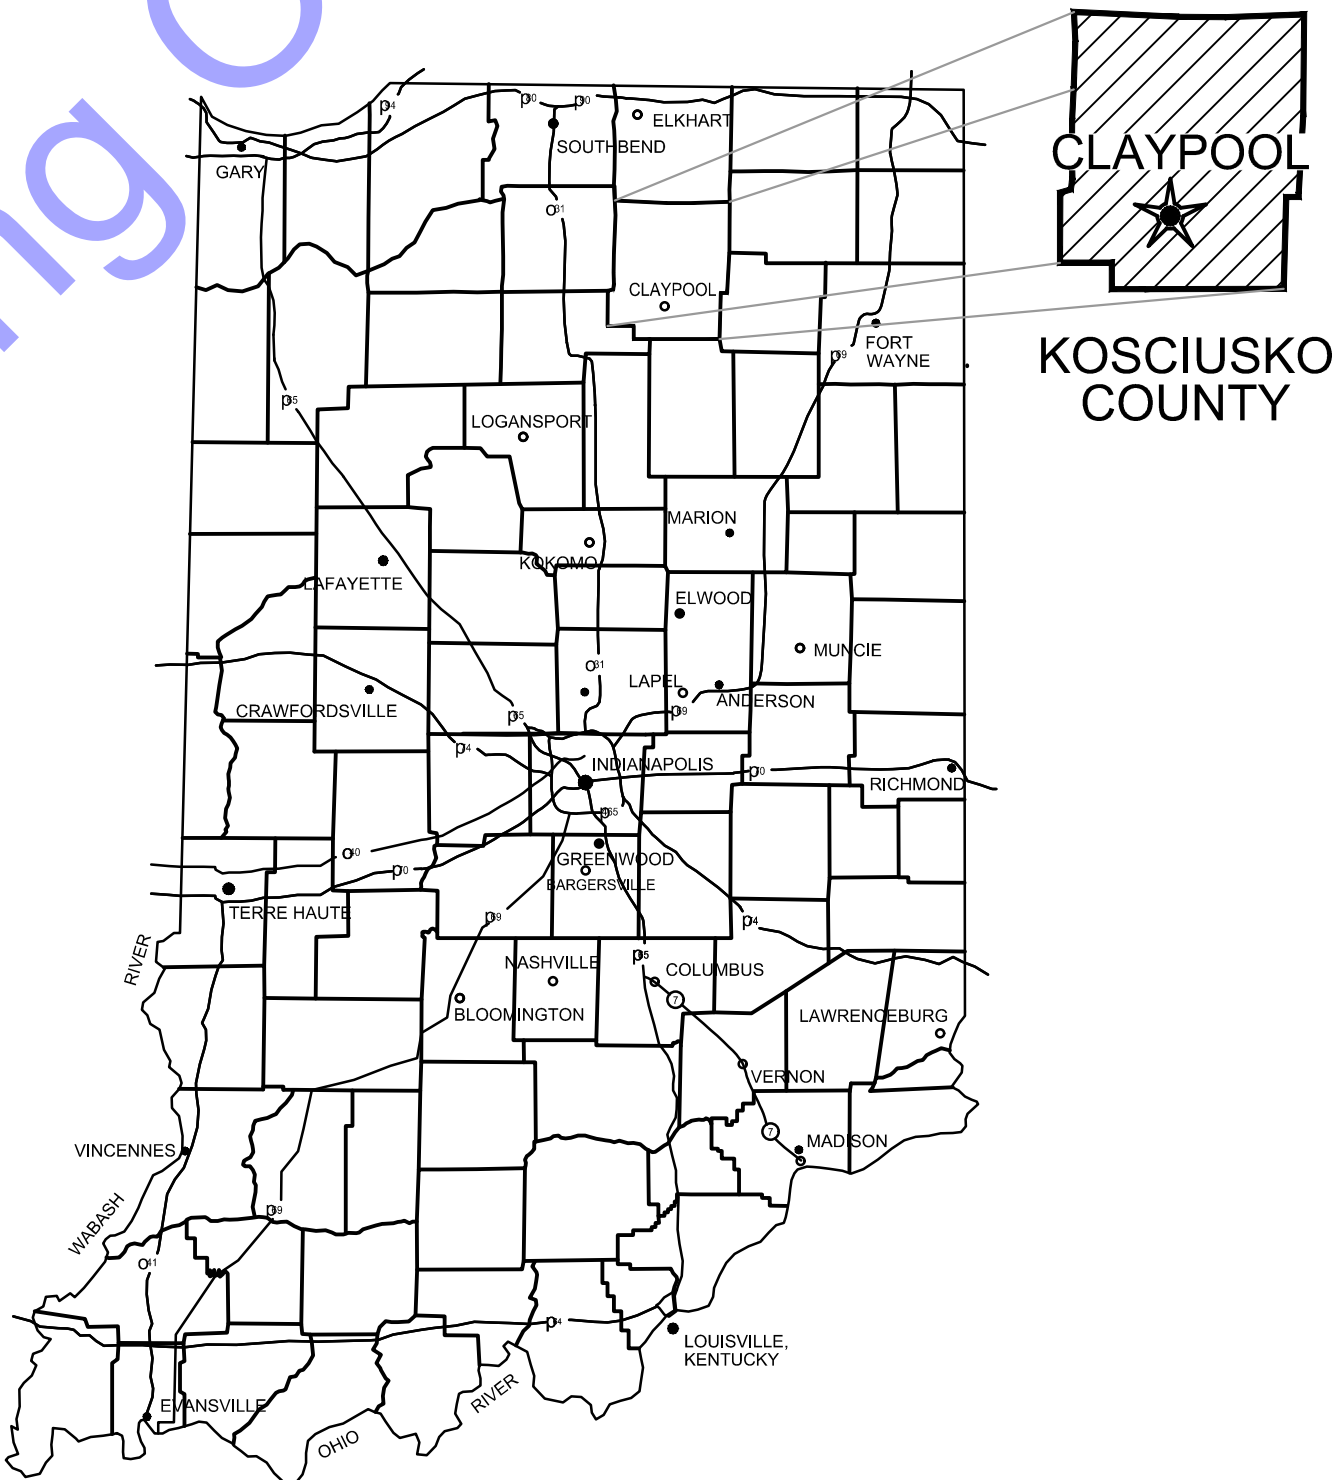


GENERAL LOCATION MAP

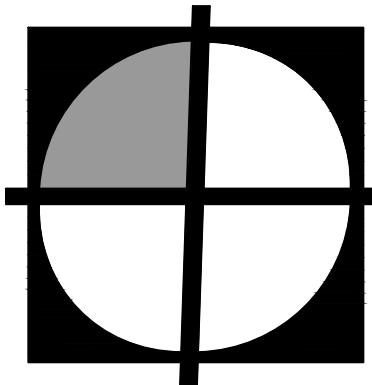


COMMONWEALTH
ENGINEERS, INC.
A wealth of resources to master a common goal.

QA/QC BY : BENJAMIN H. ADAMS
DATE : 12/31/2024

CERTIFIED BY : *Natalie M. Schelling*
NATALIE M. SCHELLING
INDIANA PE No. 12000721
DATE : 12/31/2024

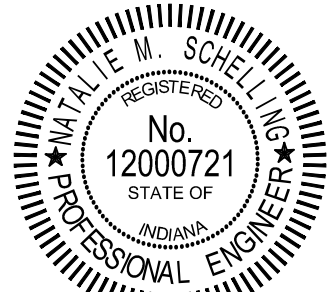


CONTRACT NO. : 23130

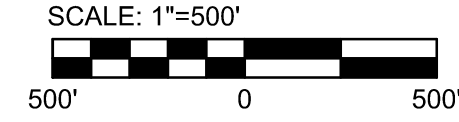

INDEX TO SHEETS		
SHEET #	DRAWING #	DESCRIPTION
1	G1	TITLE SHEET
2	G2	VICINITY MAP AND INDEX TO SHEETS
3	G3	LEGENDS, GENERAL NOTES, ABBREVIATIONS AND UTILITY CONTACTS AND NOTES
4	G4	GENERAL LOCATION PLAN & SHEET LOCATION
5	G5	CONTROL PLAN & SCHEDULE
6	G6	STRUCTURE TABLE
7	PP1	PLAN & PROFILE - LINE 'A' - STATION 0+00-4+50
8	PP2	PLAN & PROFILE - LINE 'B' - STATION 0+00-3+42
9	PP3	PLAN & PROFILE - LINE 'C' - STATION 0+00-3+04
10	PP4	PLAN & PROFILE - LINE 'D' - STATION 0+00-5+10, LINE 'D-1' - STATION 0+00-5+55
11	PP5	PLAN & PROFILE - LINE 'F' - STATION 0+00-1+25
12	PP6	PLAN & PROFILE - LINE 'E' - STATION 0+00-3+55
13	SS1	STRUCTURE DETAILS
14	SS2	STRUCTURE DETAILS
15	SS3	STRUCTURE DETAILS
16	MD1	MISCELLANEOUS DETAILS
17	MD2	MISCELLANEOUS DETAILS
18	EC1	EROSION CONTROL
19	EC2	EROSION CONTROL
20	EC3	EROSION CONTROL
21	EC4	EROSION CONTROL DETAILS



COMMONWEALTHTM
ENGINEERS, INC.
A wealth of resources to master a common goal.

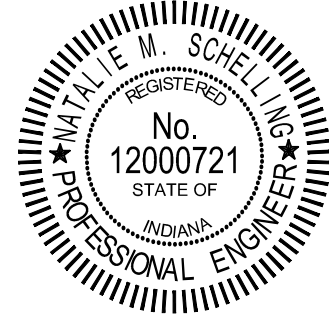

Signature Natalie Schelling Date 12/31/2024

**TOWN OF CLAYPOOL
KOSCIUSKO COUNTY, INDIANA**

CONTRACT C - STORM SEWER IMPROVEMENTS

© 2024 BY COMMONWEALTH ENGINEERS, INC. ALL RIGHTS RESERVED. REPRODUCTION BY ANY METHOD IN WHOLE OR IN PART WITHOUT PERMISSION IS PROHIBITED.



1-800-382-5544
(ITS THE LAW)

[illegible]

Designed By: BW	Drawn By: CH	Checked By: NS
--------------------	-----------------	-------------------

Issue Date: 12/2024	Project No: S23130	Scale: AS SHOWN
------------------------	-----------------------	--------------------

VICINITY MAP AND
INDEX TO SHEETS

Drawing No:

G2

Sheet: 2 OF 21

GENERAL ABBREVIATIONS

AB	AIR	G	GAS	SECT	SECTION
AFF	ANCHOR BOLT	GALV	GALVANIZED	SF	SQUARE FEET
ALT	ABOVE FINISH FLOOR	GEN	GENERAL	SHT	SHEET
ALUM	ALTERNATE	GRD	GROUND OR GRADE	SL	SAMPLE LINE
@	ALUMINUM			SOS	STORM SEWER
APP.	AT	HB	HOSE BIBB	SP	STOP PLATE
ATT	APPARENT	HORIZ	HORIZONTAL	SQ	SQUARE
AUTO	AERATION TANK TRANSFER	HP	HORSEPOWER	STD	STANDARD
AVG	AUTOMATIC	HW	HOT WATER	S STL, SS	STAINLESS STEEL
	AVERAGE			STL	STEEL
B		ID	INSIDE DIAMETER	SUP	SUPERNATANT
BLDG	BAFFLE	IJ	ISOLATION JOINT	SY	SQUARE YARD
BM	BUILDING	INV	INVERT		
BOT	BENCH MARK	IP	IRON PIN	TOS	TOP OF SLAB
BRG	BOTTOM			TOW	TOP OF WALL
	BEARING	LAV	LAVATORY	TW	TERTIARY WATER
		LB	POUND	TYP	TYPICAL
CFM	CUBIC FEET PER MINUTE	LL	LIVE LOAD		
CL	CENTERLINE	LLV	LONG LEG VERTICAL	V	VACUUM OR VALVE
CO	CLEAN OUT	LTG	LIGHTING	VAR	VARIABLES
COL/C	COLUMN			VERT	VERTICAL
CONC	CONCRETE	MAX	MAXIMUM		
COP	COPPER	MCC	MOTOR CONTROL CENTER	W	WEIR
CJ	CONSTRUCTION JOINT	MGD	MILLIONS GALLONS PER DAY	W/	WITH
CW	COLD WATER	MH	MANHOLE	W/O	WITHOUT
CY	CUBIC YARD	MIN	MINIMUM, MINUTE	WAS	WASTE ACTIVATED SL
		MJ	MECHANICAL JOINT	WC	WATER CLOSET
D	DRAIN			WH	WATER HEATER
DEC	DECANT	NC	NORMALLY CLOSED	WL	WATER LINE
DIA	DIAMETER	NG	NATURAL GAS	WWF	WELDED WIRE FABRIC
DIM	DIMENSION	NIC	NOT IN CONTACT		
DI	DUCTILE IRON PIPE	NO	NORMALLY OPEN	YH	YARD HYDRANT
DL	DEAD LOAD	NO.	NUMBER		
DSPT	DOWN SPOUT	NPW	NON-POTABLE WATER		
DWG	DRAWING				
		OC	ON CENTER		
E	ELECTRICAL CONDUIT	OD	OUTSIDE DIAMETER		
EA	EACH	OPG	OPENING		
EF	EACH FACE	OPP	OPPOSITE		
EFFL	EFFLUENT				
EL	ELEVATION	PB	PULL BOX		
EW	EACH WAY	PE	POLYETHYLENE EXP. JT.		
EX	EXISTING		MATERIAL		
EXF	EXHAUST FAN	P/L	PROPERTY LINE		
EXP JP	EXPANSION JOINT	POJ	PUSH ON JOINT		
		PSF	POUNDS PER SQUARE FOOT		
		PSI	POUNDS PER SQUARE INCH		
F	FILTER	PVC	POLYVINYL CHLORIDE		
FCAR	FLANGED COUPLING ADAPTER,	PW	POTABLE WATER		
RESTRAINED					
FD	FLOOR DRAIN				
FDN	FOUNDATION	R	RECIRCULATION		
FH	FIRE HYDRANT	RAD	RADIUS		
FLD	FILTRATE DRAIN	RAS	RETURN ACTIVATED SLUDGE		
FLG	FLANGE	RCP	REINFORCED CONCRETE PIPE		
FL	FLUSHING LINE	RD	ROOF DRAIN		
FLR	FLOOR	REINF	REINFORCING		
FM	FORCE MAIN	REQ'D	REQUIRED		
FRP	FIBER REINFORCED PLASTIC	R/W (ROW)	RIGHT-OF-WAY		
FT	FEET OR FOOT				
FTG	FOOTING	SAN	SANITARY		
FW	FINISHED WATER	SAS	SANITARY SEWER		
		SCH	SCHEDULE		

GENERAL NOTES

- IF ANY ERRORS OR DISCREPANCIES BECOME APPARENT, THEY SHALL BE BROUGHT TO THE ATTENTION OF THE ENGINEER PRIOR TO CONSTRUCTION SO THAT CLARIFICATION OR REDESIGN MAY OCCUR.
- LIMITS OF CONSTRUCTION SHALL BE WITHIN EXISTING RIGHT-OF-WAYS UNLESS OTHERWISE NOTED.
- FOR AREAS OUTSIDE OF EXISTING RIGHT-OF-WAYS, THE CONTRACTOR SHALL CONFINE ALL WORK TO THE LIMITS OF PERMANENT AND TEMPORARY EASEMENTS OR CONSTRUCTION LIMIT BOUNDARIES AS SHOWN ON THE DRAWINGS.
- THE CONTRACTOR SHALL BE RESPONSIBLE FOR SECURING, AT NO ADDITIONAL COST TO THE TOWN, TEMPORARY EASEMENTS NEEDED FOR STORAGE, STOCKPILING, ACCESS, OR ANY OTHER REASON, OUTSIDE OF ANY EASEMENTS OR RIGHT-OF-WAY PROVIDED.
- THE CONTRACTOR SHALL COORDINATE THE ACTIVITIES OF THEIR PERSONNEL, SUBCONTRACTORS, AND UTILITIES PERFORMING WORK ON THIS PROJECT. THE CONTRACTOR SHALL ALSO COORDINATE WITH THE OWNER'S OPERATIONS AND MAINTENANCE PERSONNEL WHO MAY BE WORKING IN OR NEAR THE PROJECT AREA.
- THE CONTRACTOR IS SOLELY AND COMPLETELY RESPONSIBLE FOR JOB SITE CONDITIONS DURING THE COURSE OF CONSTRUCTION OF THIS PROJECT, INCLUDING EROSION CONTROL AND THE SAFETY OF ALL PERSONS AND PROPERTY. THIS REQUIREMENT SHALL APPLY CONTINUOUSLY AND NOT BE LIMITED TO NORMAL WORKING HOURS, AND THE CONTRACTOR SHALL DEFEND, INDEMNIFY AND HOLD THE OWNER AND THE ENGINEER HARMLESS FROM ALL LIABILITY, REAL OR ALLEGED, IN CONNECTION WITH THE PERFORMANCE OR WORK ON THE PROJECT.
- THE CONTRACTOR SHALL BE RESPONSIBLE FOR ALL LINES, GRADES AND ELEVATIONS. ALL PIPES SHALL SLOPE UNIFORMLY BETWEEN INVERT ELEVATIONS SHOWN.
- IT IS THE RESPONSIBILITY OF THE CONTRACTOR TO REMOVE ALL MUD, DIRT, GRAVEL, AND ANY OTHER MATERIALS TRACKED ONTO ANY PUBLIC OR PRIVATE STREETS, PARKING LOTS, OR WALKS. THIS MATERIAL REMOVAL OR SWEEPING OF THE STREETS SHALL BE DONE AS FREQUENTLY AS NECESSARY TO MAINTAIN REASONABLY CLEAN AREAS. THE CONTRACTOR SHALL ALSO CONTROL DUST THROUGH THE USE OF WATERING, APPLICATION OF DUST PALLIATIVE, OR OTHER APPROVED METHODS. NO DIRECT PAYMENT WILL BE MADE FOR ANY SUCH CLEANING WORK OR DUST CONTROL.
- EXISTING SIGNS TO BE REMOVED AND RESET AFTER CONSTRUCTION SHALL BE COORDINATED WITH THE TOWN OF CLAYPOOL AND THE KOSCIUSKO COUNTY HIGHWAY DEPARTMENT.
- THE CONTRACTOR SHALL COMPLY WITH THE REQUIREMENTS OF ALL PERMITS OBTAINED FOR THE PROJECT.
- THE COST OF ABIDING BY THE PROVISIONS OR PERMITS ISSUED BY VARIOUS AGENCIES SHALL BE CONSIDERED INCIDENTAL TO THE CONTRACT. ALL ASSOCIATED BONDING REQUIREMENTS AND COSTS SHALL ALSO BE CONSIDERED INCIDENTAL TO THE CONTRACT.
- THE CONTRACTOR SHALL PRESERVE AND PROTECT PROPERTY MARKERS, SECTION CORNERS, SURVEY MARKS AND BENCHMARKS, SUCH AS STONES, PIPES, OR OTHER MONUMENTS ENCOUNTERED. IF THE CONTRACTOR MUST DISTURB THE PROPERTY MARKERS OR MONUMENTS, THEIR HORIZONTAL AND VERTICAL LOCATION SHALL BE DETERMINED AND RECORDED BY A REGISTERED LAND SURVEYOR AND THE OWNER NOTIFIED BEFORE DISTURBING. ALL PROPERTY MARKERS AND MONUMENTS DISTURBED DURING CONSTRUCTION SHALL BE RE-ESTABLISHED BY A REGISTERED LAND SURVEYOR TO FINAL COMPLETION.
- ROADWAY SURFACING AND BASE MATERIALS OR OTHER PROPERTY REMOVED OR DAMAGED, SHALL BE REPLACED OR REPAIRED AS PROVIDED FOR IN THE CONTRACT DOCUMENTS.
- REGRADE AREAS AS NECESSARY WITHIN THE CONSTRUCTION LIMITS TO ALLOW PROPER DRAINAGE TO EXISTING STORM SEWER STRUCTURES. ANY EXCESS SOIL AND SPOIL MATERIAL SHALL BE DISPOSED OF BY THE CONTRACTOR OFF-SITE.
- WORK NOT SPECIFIED FOR PAYMENT AS OR PART OF A SPECIFIC PAY ITEM SHALL BE CONSIDERED INCIDENTAL TO THE CONTRACT BY THE CONTRACTOR.
- COORDINATION AND PROPER FIT AND SURVEY OF ALL PROJECT ELEMENTS ARE THE RESPONSIBILITY OF THE CONTRACTOR. CONTRACTOR SHALL CONDUCT A PRE-CONSTRUCTION STAKEOUT OF THE PROJECT ELEMENTS TO VERIFY THE COORDINATES PROVIDED.
- THE CONTRACTOR SHALL VERIFY ALL RIM ELEVATIONS OF PROPOSED STRUCTURES PRIOR TO ORDERING ANY MATERIALS.
- ADDITIONAL ACCESS ROAD OUTSIDE OF WHAT IS SHOWN ON DRAWINGS, SHALL BE INCIDENTAL TO OTHER PAY ITEMS.
- ALL NORTHINGS AND EASTINGS PROVIDED FOR NEW STRUCTURES ARE DESIGNATED TO THE CENTER OF THE STRUCTURE.

EXISTING UTILITY NOTES

- THE EXISTING UTILITY INFORMATION SHOWN ON THESE DRAWINGS CONCERNING TYPE AND LOCATION OF UNDERGROUND UTILITIES IS NOT GUARANTEED TO BE ACCURATE OR ALL-INCLUSIVE. LOCATION, SIZE AND MATERIAL SHOWN ON UTILITIES ARE FROM AVAILABLE RECORDS AND AVAILABLE FIELD MARKINGS, SUPPLIED BY THE RESPECTIVE UTILITY COMPANY. THE INDIANA UNDERGROUND PLANT PROTECTION SERVICE (IUPPS) MUST BE NOTIFIED 48 HOURS PRIOR TO ANY EXCAVATION FOR VERIFICATION OF LOCATION, SIZE AND MATERIAL FOR EXISTING UNDERGROUND UTILITIES (1-800-382-5544).
2. SIZE, MATERIAL, DEPTH AND LOCATION OF KNOWN EXISTING SEWER FACILITIES ARE FROM AVAILABLE HISTORIC INFORMATION AND ABOVE-GROUND INSPECTION AND MEASUREMENT. THE CONTRACTOR SHALL VERIFY ALL SEWER INFORMATION CONTAINED IN THE CONTRACT DOCUMENTS PRIOR TO ANY CONSTRUCTION WHICH WOULD BE IMPACTED BY FACILITIES NOT LOCATED AS SHOWN IN THE CONTRACT DOCUMENTS. THE COST TO CORRECT ANY FACILITIES INSTALLED PRIOR TO VERIFICATION OF EXISTING CONDITIONS BY THE CONTRACTOR SHALL BE AT NO COST TO THE OWNER OR ENGINEER. DIFFERING CONDITIONS DISCOVERED DURING VERIFICATION WILL BE HANDLED PER THE CONTRACT DOCUMENTS
3. THE LOCATIONS OF UTILITIES AND STRUCTURES, BOTH SURFACE AND SUBSURFACE, ARE SHOWN ON THE PLANS FROM DATA AVAILABLE AT THE TIME OF SURVEY AND ARE NOT NECESSARILY COMPLETE OR CORRECT. DETERMINING THE EXACT LOCATION AND PROTECTING UTILITIES AND STRUCTURES ARE THE RESPONSIBILITY OF THE CONTRACTOR. DURING CONSTRUCTION, THE CONTRACTOR SHALL PROTECT ALL EXISTING UTILITIES AND STRUCTURES WHETHER SHOWN ON THE PLANS OR NOT. IF DAMAGE IS CAUSED, THE CONTRACTOR SHALL BE RESPONSIBLE FOR THE REPAIR AND RESTORATION OF SAME IN ACCORDANCE WITH THE REQUIREMENTS OF THE UTILITY OWNER AND FOR ANY RESULTING CONTINGENT DAMAGE AND COST.
4. IF UTILITY FACILITIES OTHER THAN THOSE SHOWN ARE LOCATED, OR IF UTILITIES ARE LOCATED WHICH ARE NOT IN ACCORDANCE WITH THE LOCATIONS SHOWN ON THE DRAWINGS, THE ENGINEER SHALL BE NOTIFIED TO DETERMINE IF PLAN REVISIONS ARE NEEDED.
5. ALL EXISTING UTILITIES SHOWN IN PROFILE ARE INDICATED AT THEIR ASSUMED ELEVATION. CONTRACTOR TO FIELD VERIFY PRIOR TO CONSTRUCTION.
6. IN GENERAL, UTILITY SERVICE LINES TO INDIVIDUAL CUSTOMERS ARE NOT SHOWN ON THE PLANS. CONTRACTOR SHALL ASSUME THAT UNDERGROUND SERVICE LINES EXIST TO EACH PROPERTY ALONG THE NEW SEWER ROUTE FOR WATER, SANITARY SEWER, GAS, ELECTRIC, TELEPHONE, AND FIBER OPTIC. THE CONTRACTOR SHALL LOCATE, PROTECT, AND IF DAMAGED BY CONTRACTOR, REPAIR ALL UTILITY SERVICE LINES ENCOUNTERED.
7. IT SHALL BE THE CONTRACTOR'S RESPONSIBILITY TO MAINTAIN IN SERVICE ALL EXISTING UTILITIES ENCOUNTERED DURING CONSTRUCTION UNLESS OTHERWISE INDICATED IN THE DRAWINGS. ANY UTILITY WHICH CAN BE REMOVED DURING CONSTRUCTION WITHOUT UNDUE INTERRUPTION OF SERVICE MAY BE REMOVED AND REPLACED BY THE CONTRACTOR WITH THE PERMISSION OF THE OWNER AND THE APPLICABLE UTILITY OWNER.
8. THE CONTRACTOR SHALL BE RESPONSIBLE FOR REPAIR/REPLACEMENT TO ALL DAMAGED WATER SERVICES. CONTRACTOR MUST NOTIFY WATER MAINTENANCE AND SERVICE DISPATCHER OF ANY DAMAGES TO THE WATER FACILITIES. DAMAGED WATER FACILITIES MUST BE REPAIRED BY THE CONTRACTOR WITHIN TWO (2) HOURS AT NO ADDITIONAL COST TO THE OWNER. IF WATER MAINTENANCE IS REQUIRED TO MAKE REPAIRS, THE CONTRACTOR WILL BE BILLED. WATER MAIN REPLACEMENT SHALL BE COORDINATED WITH HIGHLAND WATER DEPARTMENT AND SHALL BE COMPLETED IN CONFORMANCE TO THE CONTRACT DOCUMENTS.
9. THE CONTRACTOR SHALL PROTECT ALL POWER POLES FROM DAMAGE ASSOCIATED WITH CONSTRUCTION ACTIVITIES. WHERE REQUIRED, ALL UTILITY POLES ARE TO BE SUPPORTED IN A MANNER APPROVED BY THE APPROPRIATE UTILITY DURING INSTALLATION OF SEWER PIPE. ALL COSTS ASSOCIATED WITH MAINTAINING SAID FLOWS SHALL BE THE RESPONSIBILITY OF THE CONTRACTOR. ALL COSTS ASSOCIATED WITH THE PROTECTION AND/OR TEMPORARY SUPPORT OF UTILITY POLES SHALL BE THE RESPONSIBILITY OF THE CONTRACTOR.
10. THE CONTRACTOR SHALL MAKE PROVISIONS TO MAINTAIN FLOWS IN ALL SANITARY SEWERS, AND OVERFLOWS ARE PROHIBITED. BYPASS PUMPING OR ALTERNATE PROVISIONS MAY BE REQUIRED AND SHALL BE SUFFICIENT TO CONVEY FLOWS UNDER ALL CONDITIONS. ALL COSTS ASSOCIATED WITH MAINTAINING SAID FLOWS SHALL BE THE RESPONSIBILITY OF THE CONTRACTOR.

UTILITY CONTACT INFORMATION

UTILITY CONTACT INFORMATION				
UTILITY PROVIDER	UTILITY TYPE	CONTACT	PHONE	ADDRESS
TOWN OF CLAYPOOL	SEWER	DANNY WARNER	(574) 566-2322	utilities@townofclaypool.com PO BOX 6 CLAYPOOL, IN 46510
AT&T - TRANSMISSION	FIBER OPTIC	VANESSA ROSS	(217) 381-4284	Vf2021@att.com 555 E. COOK STREET SPRINGFIELD, IL 62703
FRONTIER	TELEPHONE		(260) 459-7759	4027 BECKWITH DR FORT WAYNE, IN 46808
IN AMERICAN WATER	WATER	RYAN MOORE	(317) 885-2404	inutilitycoordination@amwater.com
IN FIBER NETWORK DBA INTELLIGENT FIBER NETWORK	FIBER OPTIC	WAYLON HIGGINS		zaya.relo@indiana@zayo.com 722 N. HIGH SCHOOL ROAD INDIANAPOLIS, IN 46214
KOSCIUSKO R.E.M.C., FIBER	FIBER OPTIC			
NIPSCO GAS & ELECTRIC (GOSHEN)	ELECTRIC, GAS	UTILITY COORDINATION		utilitycoordination@nisource.com
	ELECTRIC, GAS	DAMAGE PREVENTION SCREENING CENTER		cdcdamagepreventioncenter@nisource.com
WARSAW COMMUNITY SCHOOLS	FIBER OPTIC	TERRY ENGLE	(574) 371-5098 x2412	tengle@warsawschools.org PO BOX 288 WARSAW, IN 46580

LEGEND

PLAN ONLY		PLAN ONLY		PLAN ONLY		PLAN ONLY	
	NEW TEMPORARY EASEMENT (PLAN ONLY)		NEW STORM MANHOLE		EXISTING GAS METER		EXISTING WATER METER
	NEW PERMANENT EASEMENT (PLAN ONLY)		NEW STORM SEWER		EXISTING FIBER OPTICS		EXISTING GAS LINE
	GRANULAR BACKFILL (PROFILES AND SECTIONS ONLY)		NEW STORM INLET		EXISTING FIBER OPTICS BOX		EXISTING GAS VALVE
	ASPHALT (PROFILES AND SECTIONS ONLY)		EXISTING SANITARY MANHOLE		EXISTING ELECTRIC BOX		EXISTING LIGHT POLE
	ABANDONED IN PLACE (PLAN ONLY)		EXISTING SANITARY SEWER		EXISTING MAILBOX		EXISTING POWER POLE/GUY WIRE
	STONE DRIVE (PLAN ONLY)		EXISTING STORM SEWER TO BE PLUGGED		EXISTING SIGN		EXISTING BURIED TELEPHONE
	GROUT (PROFILES AND SECTIONS ONLY)		EXISTING STORM SEWER TO BE ABANDONED/FILLED		EXISTING POST		EXISTING TELEPHONE CONTROL BOX
	CONCRETE		EXISTING STORM SEWER TO BE REMOVED		EXISTING GUARDRAIL		EDGE OF DRIVE
	DROP SHAFT LOCATION (PLAN ONLY)		EXISTING FORCE MAIN		EXISTING DECIDUOUS TREE		EXISTING SPOT ELEVATION
			EXISTING STORM STRUCTURE		EXISTING EVERGREEN TREE		CONTROL POINT
			EXISTING STORM SEWER		EXISTING SHRUB/BUSH		TEMPORARY BENCH MARK
			EXISTING STORM SEWER		EXISTING TREE LINE		WATER EDGE
			EXISTING WATERLINE		EXISTING MAJOR CONTOUR LINE		EXISTING BIG ROCK
			EXISTING FIRE HYDRANT		EXISTING MINOR CONTOUR LINE		CONSTRUCTION LIMITS/TRENCH LIMITS
			EXISTING WATER VALVE		APPROX. RIGHT-OF-WAY		
			EXISTING WATER SPIGOT		APPROX. PROPERTY LINE		

 COMMONWEALTH ENGINEERS, INC. REGISTERED PROFESSIONAL ENGINEERS A member of resources to make a common good. https://commonwealthengineers.com/		OFFICE LOCATIONS IN: INDIANAPOLIS, IN (2) EVANSVILLE, IN FORT WAYNE, IN CROWN POINT, IN BOWLING GREEN, KY. SOUTH BEND, IN.	
 <i>Nathaniel Schell</i> Signature 12/31/2024 Date			
TOWN OF CLAYPOOL KOSCIUSKO COUNTY, INDIANA		CONTRACT C - STORM SEWER IMPROVEMENTS	
© 2024 BY COMMONWEALTH ENGINEERS, INC. ALL RIGHTS RESERVED. REPRODUCTION BY ANY MEANS WITHOUT PERMISSION IS PROHIBITED  Indiana 811 Know what's below. Dig before you dig. 1-800-382-5544 (IT'S THE LAW)			
Designed By: BW		Drawn By: CH	
Issue Date: 12/2024		Project No: S23130	
Scale: AS SHOWN			
LEGENDS, GENERAL NOTES, ABBREVIATIONS AND UTILITY CONTACTS AND NOTES			
Drawing No: G3			
Sheet: 3 OF 21			



<https://www.utwente.nl>



© 2024 BY COMMONWEALTH ENGINEERS, INC. ALL RIGHTS RESERVED. REPRODUCTION BY ANY METHOD IN WHOLE OR IN PART WITHOUT PERMISSION IS PROHIBITED

**Know what's below.
Call before you dig.**

Know what's below. 811 before you dig.

1-800-382-5544
(ITS THE LAW)

Designed By: BW	Drawn By: CH	Checked By: NS
Issue Date: 12/2024	Project No: S23130	Scale: AS SHOWN

Drawing No:
G4
Sheet: 4 OF 21

CONTROL
SCALE: 1"=100'-0"

<u>POINT #</u>	<u>NORTHING</u>	<u>EASTING</u>	<u>ELEVATION</u>	<u>DESCRIPTION</u>
7790	2144342.05	268776.14	874.48	TBM * NE BB IN FH CHISSELD X
9510	2143746.21	268785.64	871.75	CP * DN

CONTROL PLAN & SCHEDULE

Drawing No:
G5
Sheet: 5 OF 21

© 2024 BY COMMONWEALTH ENGINEERS, INC. ALL RIGHTS RESERVED. REPRODUCTION BY ANY METHOD IN WHOLE OR IN PART WITHOUT PERMISSION IS PROHIBITED

 Know what's below.
Call before you dig.

Know what's below. 811 before you dig.
1-800-382-5544
(ITS THE LAW)

TOWN OF CLAYPOOL KOSCIUSKO COUNTY, INDIANA	CONTRACT C - STORM SEWER IMPROVEMENTS
---	---



Signature Natalie Scheel Date 12/31/2024



**COMMONWEALTHTM
ENGINEERS, INC.[®]**

A wealth of resources to make a common goal.


<https://commonwealthengineers.com/>

OFFICE LOCATIONS IN:

- INDIANAPOLIS, IN. (2)
- EVANSVILLE, IN.
- FORT WAYNE, IN.
- CROWN POINT, IN.
- BOWLING GREEN, KY.
- SOUTH BEND, IN.

STRUCTURE TABLE					
STRUCTURE NAME:	RIM:	STRUCTURE SIZE:	CASTING TYPE:	PIPES IN:	PIPES OUT:
101	894.4±	48" DOGHOUSE MANHOLE CONTRACTOR TO FIELD VERIFY LOCATION AND DEPTH OF EXISTING CONNECTION. ADD NEW STR. #101 AND RECONNECT ALL EXISTING STORM PIPES.	R-1772	15" INV: 882.50 W (IN)	CONTRACTOR TO VERIFY
102	889.5±	48" MANHOLE	R-1772	15" INV: 883.05 N (IN)	15" INV: 882.95 E (OUT)
103	887.1±	48" MANHOLE CONTRACTOR TO FIELD VERIFY LOCATION AND DEPTH OF EXISTING CONNECTION. ADD NEW STR. #103 AND RECONNECT ALL EXISTING STORM PIPES.	R-2502 TYPE C	12" INV: 883.40 N (IN)	15" INV: 883.15 S (OUT)
104	887.2±	33" MANHOLE	R-2502 TYPE C	12" INV: 883.59 N (IN)	12" INV: 883.49 S (OUT)
105	887.8±	30" MANHOLE	R-2502 TYPE C		12" INV: 883.71 S (OUT)
106	886.0±	48" MANHOLE CONTRACTOR TO FIELD VERIFY LOCATION AND DEPTH OF EXISTING CONNECTION. ADD NEW STR. #106 AND RECONNECT ALL EXISTING STORM PIPES.	R-1772	12" INV: 881.50 NW (IN) 12" INV: 881.50 S (IN) 12" INV: 879.29 W (IN)	12" INV: 878.84 SE (OUT)
107	885.7±	48" MANHOLE	R-1772	12" INV: 880.09 W (IN) 12" INV: 882.00 SW (IN) 12" INV: 882.00 NW (IN)	12" INV: 879.99 E (OUT)
108	886.6±	48" MANHOLE	R-1772	12" INV: 880.49 W (IN) 12" INV: 882.00 NE (IN) 12" INV: 882.00 S (IN)	12" INV: 880.39 E (OUT)
109	885.3±	33" MANHOLE CONTRACTOR TO REPLACE EX. ROUND INLET WITH NEW STR. #109	R-2502 TYPE C	12" INV: 881.37 S (IN)	12" INV: 880.67 E (OUT)
110	886.1±	33" MANHOLE	R-2502 TYPE C		12" INV: 881.45 N (OUT)
111	886.4±	33" MANHOLE	R-2502 TYPE C		12" INV: 882.20 SW (OUT)
112	886.2±	33" MANHOLE	R-2502 TYPE C		12" INV: 882.20 N (OUT)
113	885.2±	33" MANHOLE	R-2502 TYPE C		12" INV: 882.10 SE (OUT)
114	885.7±	33" MANHOLE	R-2502 TYPE C		12" INV: 882.10 NE (OUT)
115	885.8±	33" MANHOLE	R-2502 TYPE C		12" INV: 881.60 SE (OUT)
116	885.7±	33" MANHOLE	R-2502 TYPE C		12" INV: 881.60 N (OUT)
118	879.4±	48" MANHOLE	R-1772	12" INV: 875.00 W (IN) 12" INV: 872.36 S (IN)	12" INV: 872.26 N (OUT)
119	880.6±	48" MANHOLE	R-2502 TYPE C	12" INV: 876.29 W (IN)	12" INV: 872.62 N (OUT)
120	879.6±	33" MANHOLE	R-2502 TYPE C		12" INV: 875.13 E (OUT)
121	877.0±	33" MANHOLE	R-2502 TYPE C		12" INV: 871.61 N (OUT)
122	873.4±	48" MANHOLE	R-2502 TYPE C	15" INV: 868.09 W (IN)	15" INV: 867.99 E (OUT)
123	874.8±	48" MANHOLE	R-2502 TYPE C	12" INV: 869.25 N (IN) 12" INV: 871.81 W (IN)	15" INV: 869.00 E (OUT)
124	876.8±	48" MANHOLE	R-2502 TYPE C	12" INV: 870.09 W (IN)	12" INV: 869.99 S (OUT)
125	874.6±	33" MANHOLE	R-2502 TYPE C	12" INV: 870.51 W (IN)	12" INV: 870.41 E (OUT)
126	878.5±	48" MANHOLE	R-2502 TYPE C		12" INV: 870.94 E (OUT)
127	875.1±	33" MANHOLE	R-2502 TYPE C	12" INV: 871.99 S (IN)	12" INV: 871.89 E (OUT)
128	873.8±	96" DOGHOUSE MANHOLE CONTRACTOR TO FIELD VERIFY LOCATION AND DEPTH OF EXISTING CONNECTION. ADD NEW STR. #128 AND RECONNECT ALL EXISTING STORM PIPES.	R-1772	12" INV: 868.60 W (IN) 12" INV: 869.88 NW (IN) 48" INV: 863.85 S (IN)	48" INV: 863.85 N (OUT)
129	873.5±	48" MANHOLE	R-2502 TYPE C	12" INV: 869.07 W (IN) 12" INV: 871.50 SW (IN) 12" INV: 871.50 NW (IN)	12" INV: 868.97 E (OUT)

STRUCTURE TABLE					
STRUCTURE NAME:	RIM:	STRUCTURE SIZE:	CASTING TYPE:	PIPES IN:	PIPES OUT:
130	873.9±	48" MANHOLE	R-2502 TYPE C		12" INV: 869.32 E (OUT)
131	873.6±	33" MANHOLE	R-2502 TYPE C		12" INV: 871.60 SE (OUT)
132	873.7±	33" MANHOLE	R-2502 TYPE C		12" INV: 871.60 NE (OUT)
133	884.7±	48" MANHOLE CONTRACTOR TO FIELD VERIFY LOCATION AND DEPTH OF EXISTING CONNECTION. ADD NEW STR. #133 AND RECONNECT ALL EXISTING STORM PIPES.	R-1772	12" INV: 878.30 E (IN) 12" INV: 874.50 W (IN)	12" INV: 874.50 S (OUT)
134	884.4±	48" MANHOLE	R-1772	12" INV: 880.26 E (IN) 12" INV: 880.39 S (IN) 12" INV: 880.43 N (IN)	12" INV: 878.66 W (OUT)
135	885.0±	48" MANHOLE	R-1772	12" INV: 880.96 NW (IN) 12" INV: 880.96 S (IN) 12" INV: 880.86 E (IN)	12" INV: 880.76 W (OUT)
136	885.3±	48" MANHOLE	R-1772		12" INV: 881.66 W (OUT)
137	884.9±	33" MANHOLE	R-2502 TYPE C		12" INV: 880.78 S (OUT)
138	884.4±	33" MANHOLE	R-2502 TYPE C		12" INV: 880.48 N (OUT)
139	884.9±	33" MANHOLE	R-2502 TYPE C		12" INV: 881.01 SE (OUT)
140	885.2±	33" MANHOLE	R-2502 TYPE C		12" INV: 881.02 N (OUT)
141	875.5±	33 MANHOLE	R-2502 TYPE C		12" INV: 872.19 N (OUT)
142	885.3±	33" MANHOLE CONTRACTOR TO REPLACE EX. ROUND INLET WITH NEW STRUCTURE #142 AND RECCONNECT EX. PIPE	R-2502 TYPE C		8" INV: 878.79 N (OUT)
143	879.8±	33" MANHOLE CONTRACTOR TO REMOVE EX. INLET #2 AND REPLACE WITH NEW STR. #143 AND RECONNECT EX. STORM	R-2502 TYPE C	6" INV: 877.25 S (IN)	8" INV: 876.30 N (OUT) 12" INV: 876.50 E (OUT)
144	872.5±	33" MANHOLE CONTRACTOR TO REMOVE EX. INLET #6 AND REPLACE WITH NEW STR. #144 AND CONNECT TO NEW STR. 128 W/ 12" INLET CONNECTION PIPE AND PLUG EX. 12" STORM TO N	R-2502 TYPE C	12" INV: 869.97 N (IN)	12" INV: 869.97 SE (OUT)
EX. INLET #1	879.9±		ROUND INLET	6" INV: 877.55 W (IN)	6" INV: 877.50 N (OUT)
EX. INLET #2	879.8±		BEEHIVE INLET	6" INV: 877.25 S (IN)	8" INV: 876.30 N (OUT)
EX. INLET #3	876.2±	CONTRACTOR TO CONNECT PROP. INLET TO EX. STORM MANHOLE #6.	ROUND INLET	48" INV: 864.18 W (IN) 12" INV: 871.11 S (IN)	48" INV: 864.13 NE (OUT)
EX. INLET #4	883.5±		BEEHIVE INLET	6" INV: 882.11 E (IN)	8" INV: 880.61 S (OUT)
EX. INLET #5	883.4±		BEEHIVE INLET	8" INV: 879.18 N (IN) 6" INV: 882.13 NE (IN)	8" INV: 879.18 S (OUT)
EX. INLET #6	873.8±		ROUND INLET	12" INV: 869.97 N (IN)	
EX. STR. #7	876.0±		MANHOLE	12" INV: 870.16 S (IN) 48" INV: 864.81 SW (IN) 12" INV: 872.11 SW (IN)	48" INV: 864.76 N (OUT)
EX. STR. #10	873.8±	CONTRACTOR TO CONNECT TO EX. STR. #10	MANHOLE	15" INV: 867.84 W (IN) 48" INV: 863.28 S (IN) 12" INV: 866.28 E (IN)	48" INV: 863.28 N (OUT)
EX. STR. #11	884.7±		MANHOLE		10" INV: 874.83 N (OUT) 12" INV: 874.50 E (OUT)
EX. STR. #12	886.0±		MANHOLE	8" INV: 878.79 S (IN) 10" INV: 878.84 N (IN) 12" INV: 878.84 NW (IN) 12" INV: 878.84 NW (IN)	12" INV: 879.29 SE (OUT)

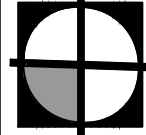


**COMMONWEALTHTM
ENGINEERS, INC.**

A wealth of resources to master a common goal.

<https://commonwealthengineers.com/>

OFFICE LOCATIONS IN:


- INDIANAPOLIS, IN. (2)
- EVANSVILLE, IN.
- FORT WAYNE, IN.
- CROWN POINT, IN.
- BOWLING GREEN, KY.
- SOUTH BEND, IN.

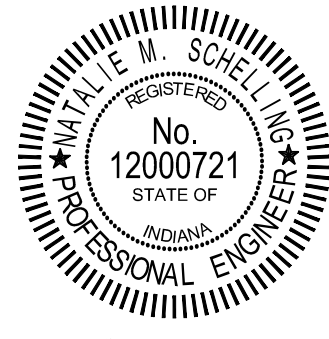

Signature Natalie Schelling Date 12/31/2024

**TOWN OF CLAYPOOL
KOSCIUSKO COUNTY, INDIANA**

CONTRACT C - STORM SEWER IMPROVEMENTS



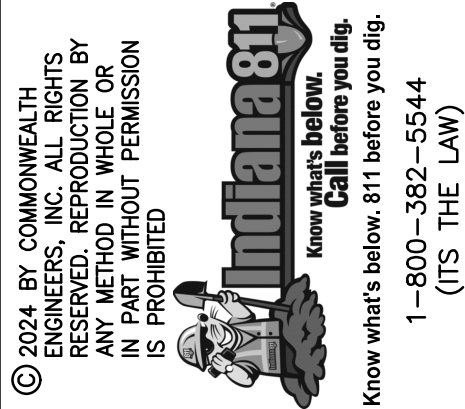
[illegible]

STRUCTURE TABLE

Drawing No:

G6


Sheet: 6 OF 21

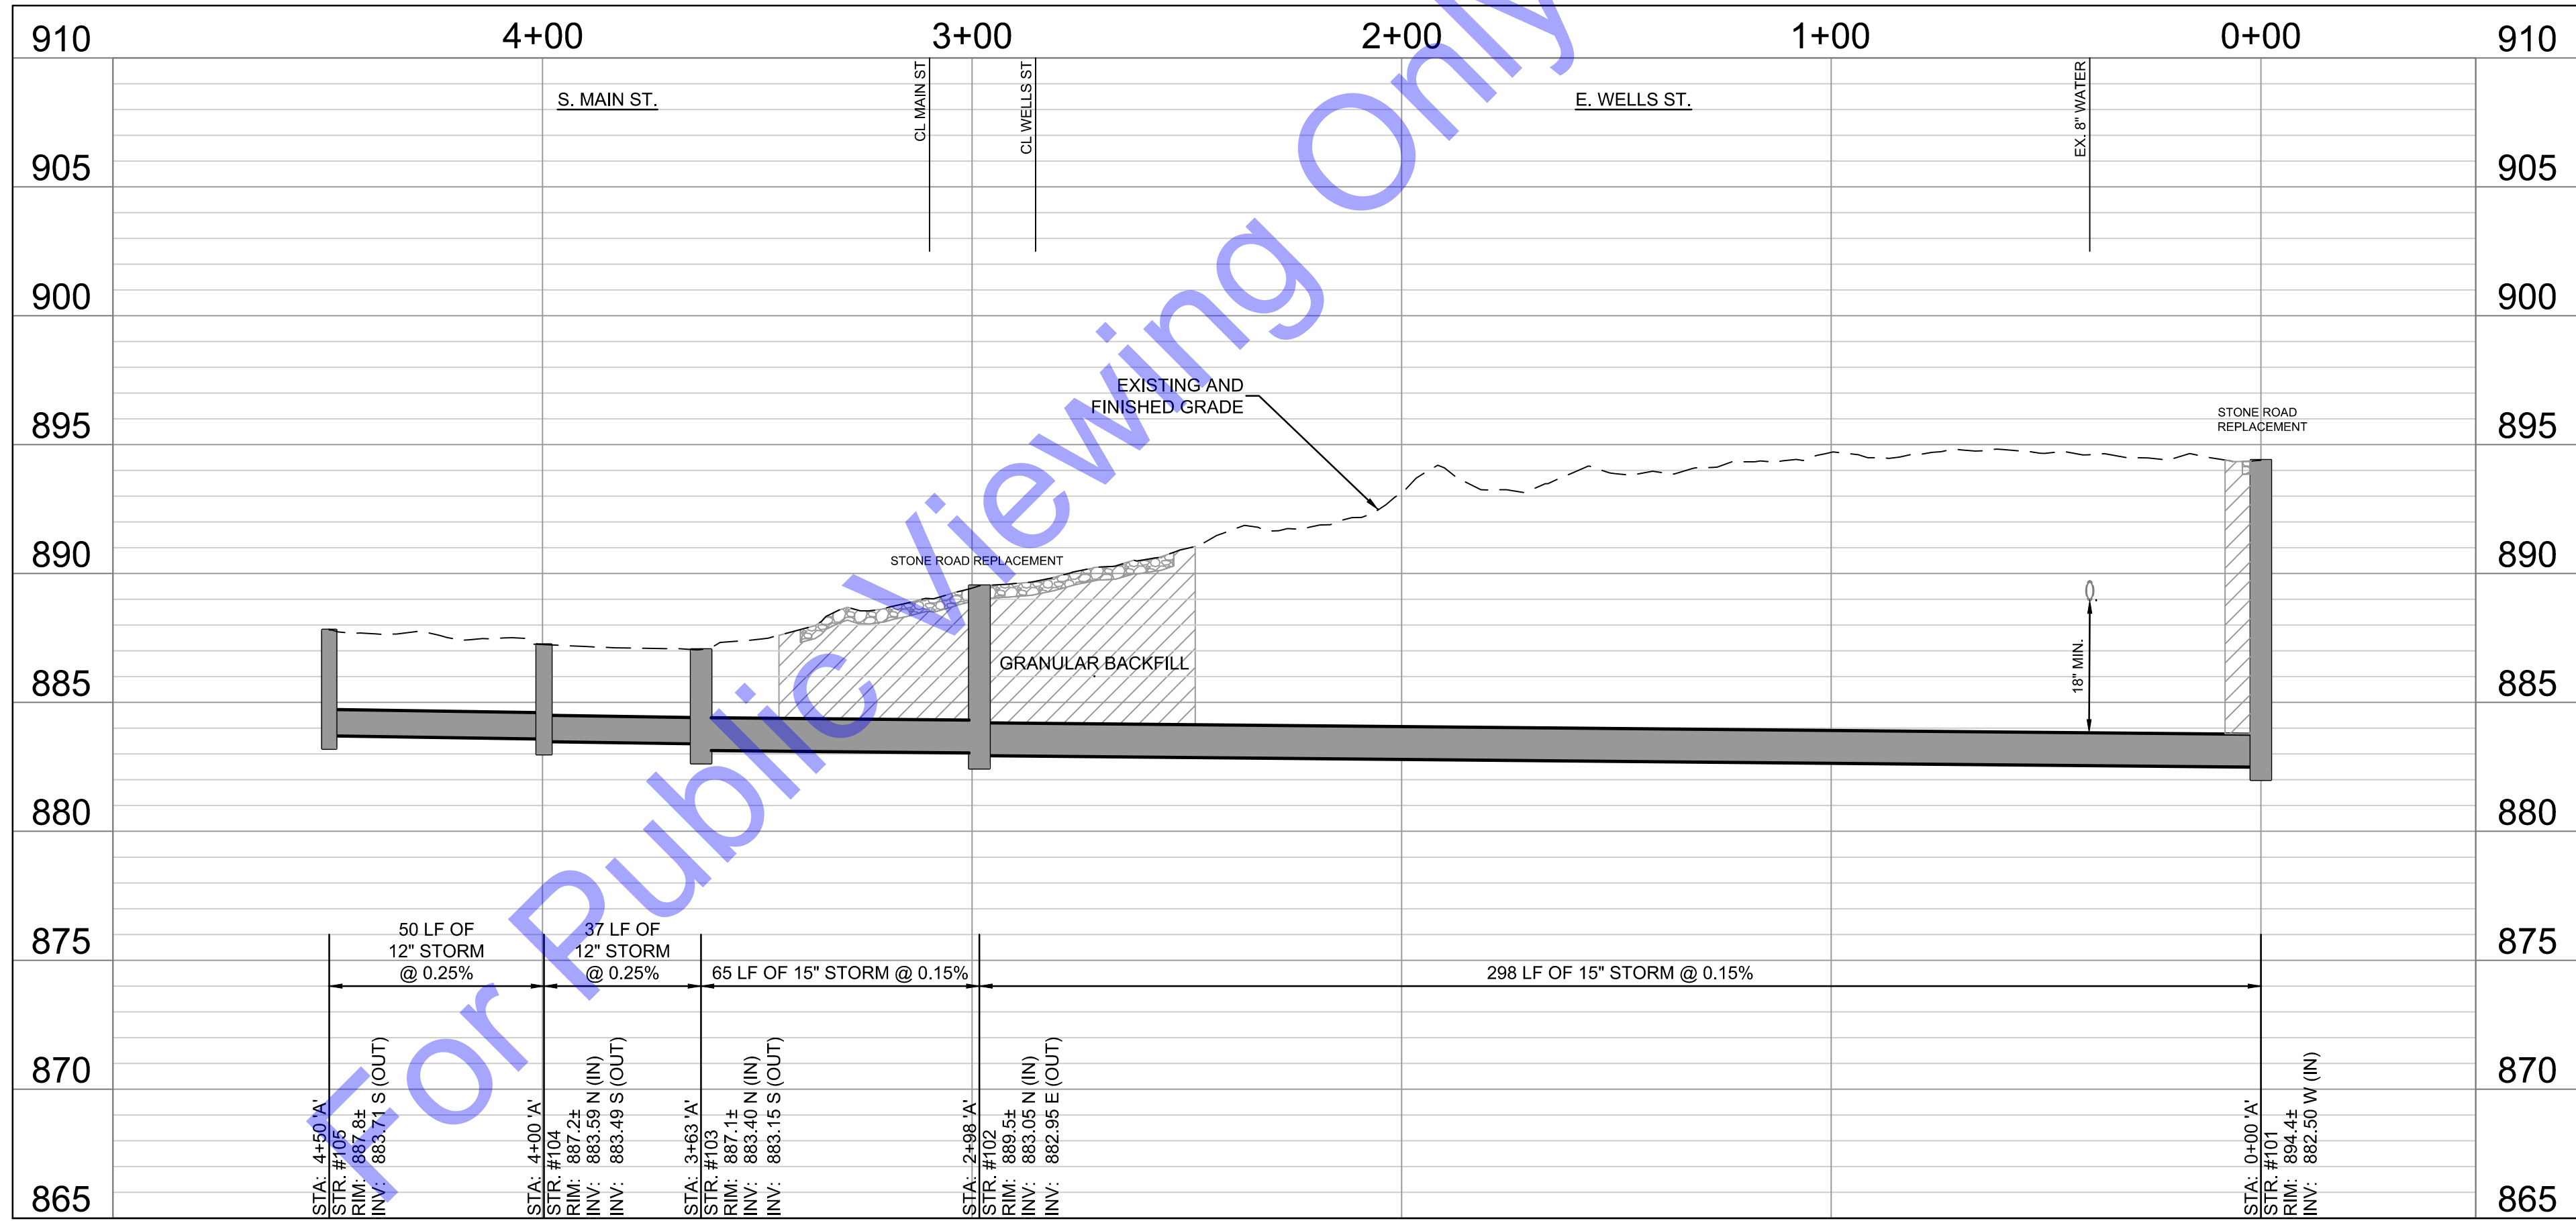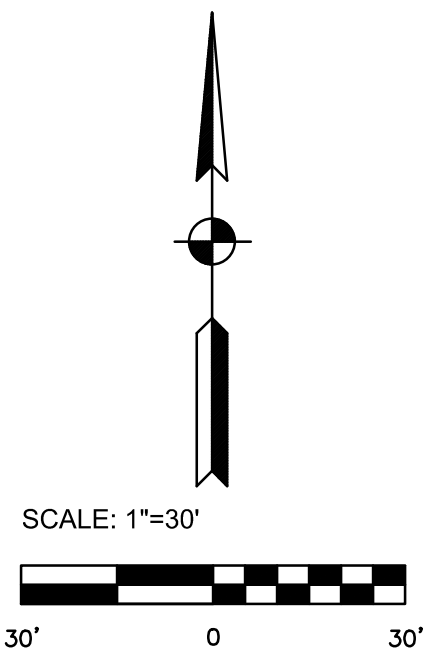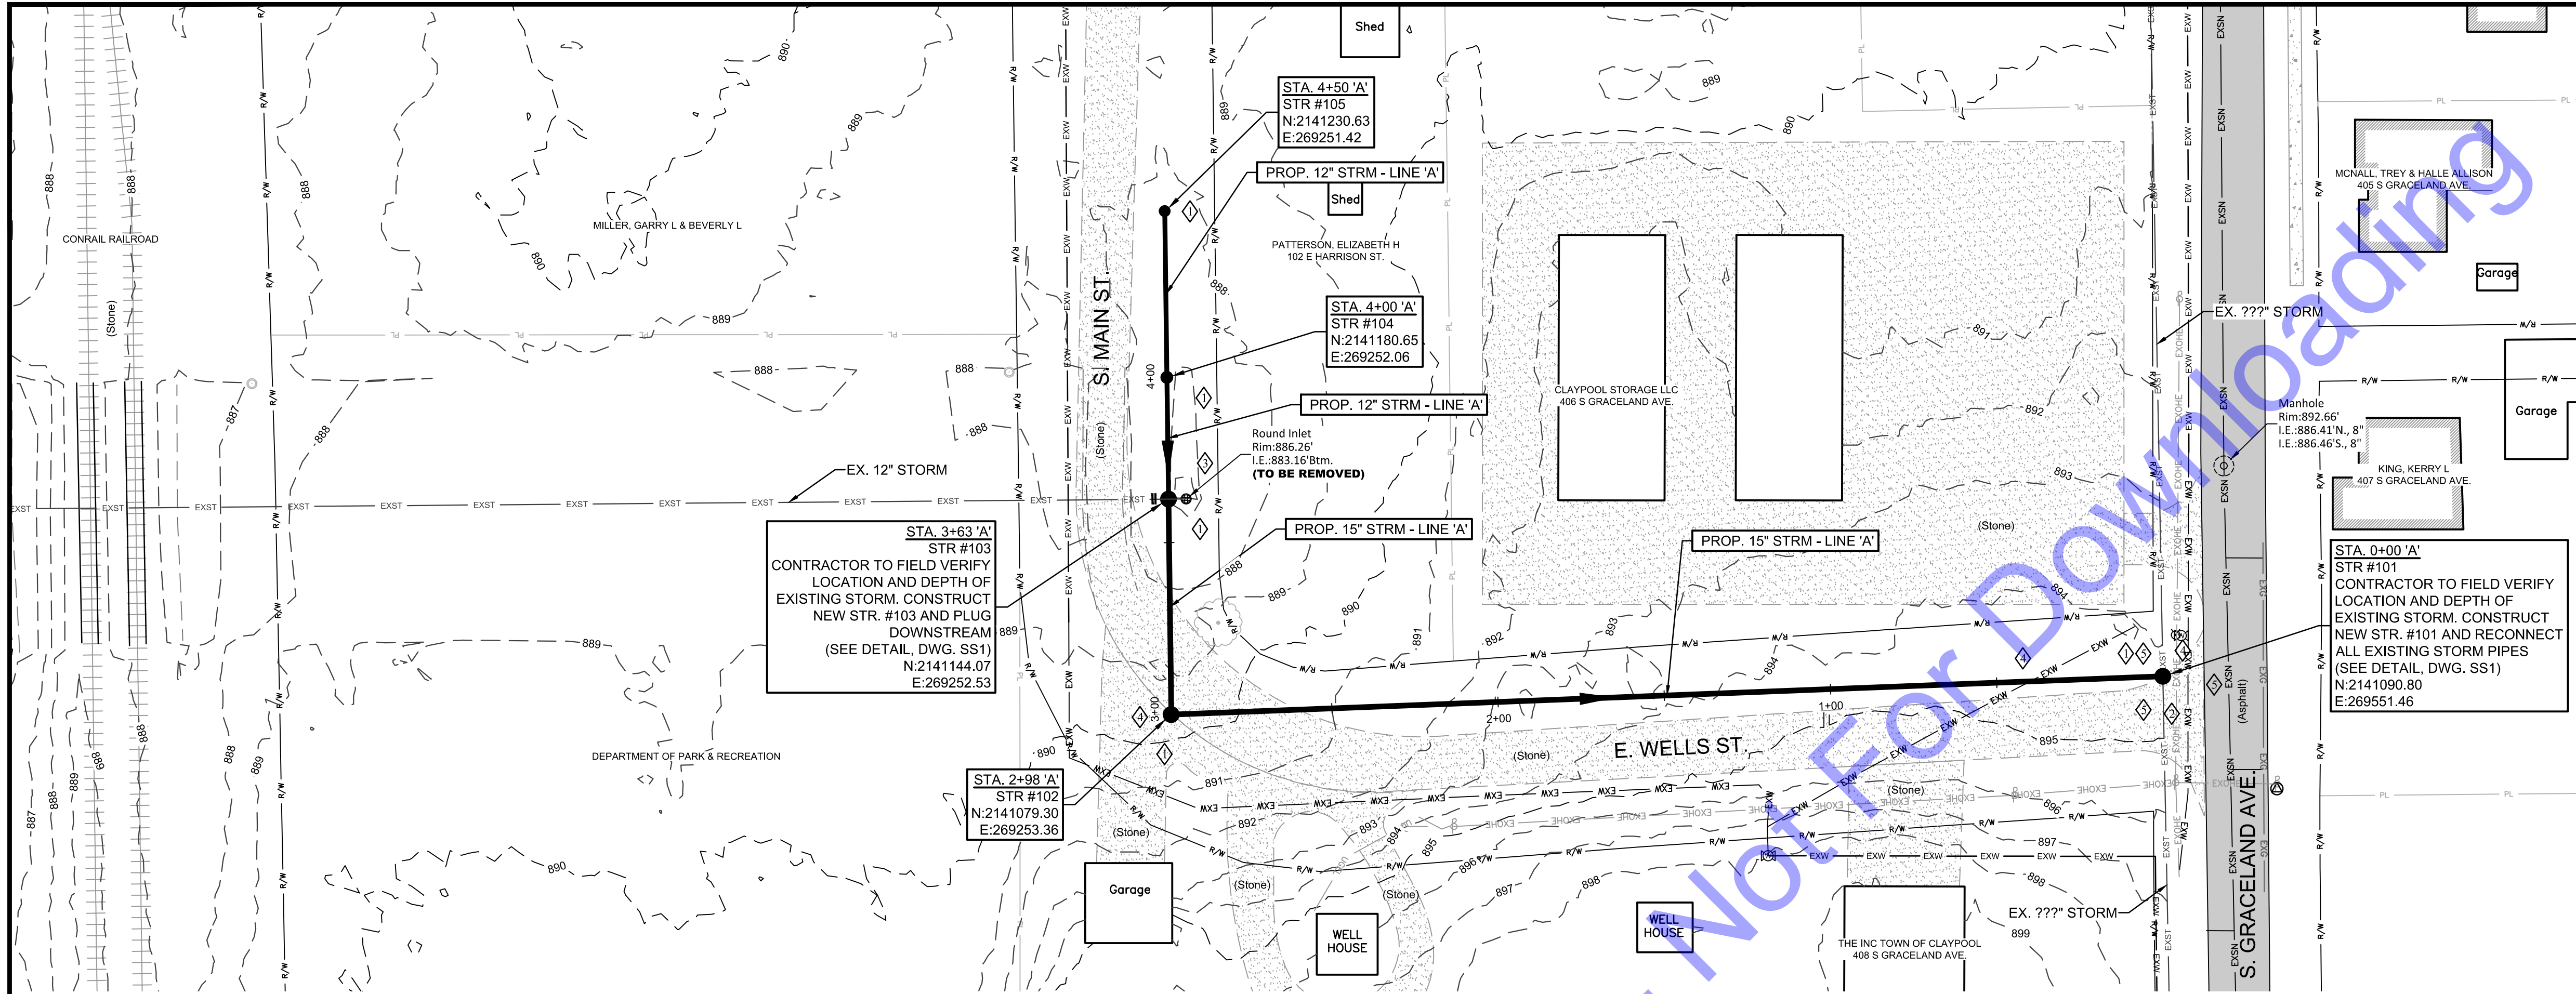

CODING NOTES

- SEE EC DRAWINGS FOR EROSION CONTROL MEASURES.
- CONTRACTOR TO VERIFY EX. UTILITY LOCATIONS PRIOR TO ANY CONSTRUCTION. IN THE EVENT OF UTILITY CONFLICTS, CONTRACTOR SHALL NOTIFY UTILITY TO RELOCATE TO AVOID CONFLICTS.
- CONTRACTOR TO PROTECT ANY EXISTING STORM SEWER AND STRUCTURES AND/OR FIELD TILE ENCOUNTERED DURING CONSTRUCTION. IF ENCOUNTERED AND DISTURBED, CONTRACTOR TO REPLACE TO A CONDITION EQUAL TO OR BETTER.
- EARLY ACTION ITEM: CONTRACTOR TO FIELD VERIFY LOCATION AND DEPTH OF EXISTING WATER MAIN PRIOR TO CONSTRUCTION ON LINE 'A'. MAINTAIN MINIMUM REQUIRED SEPARATION DURING INSTALLATION OF LINE 'A'.
- EARLY ACTION ITEM: CONTRACTOR TO FIELD VERIFY LOCATION, SIZE AND DEPTH OF EXISTING STORM SEWER PRIOR TO CONSTRUCTION ON LINE 'A'. IF EXISTING STORM INVERT IS TOO SHALLOW, NOTIFY ENGINEER PRIOR TO CONSTRUCTION. ALTERNATE ROUTE FOR LINE 'A' TO BE RE-ROUTED TO THE WEST FROM NEW STRUCTURE #103 WITH ENGINEER APPROVAL.

NOTE:
THE EXISTING AND PROPOSED PROFILE GRADES ARE BASED ON THE ELEVATIONS AT THE CENTERLINE OF THE PROPOSED STORM SEWER.

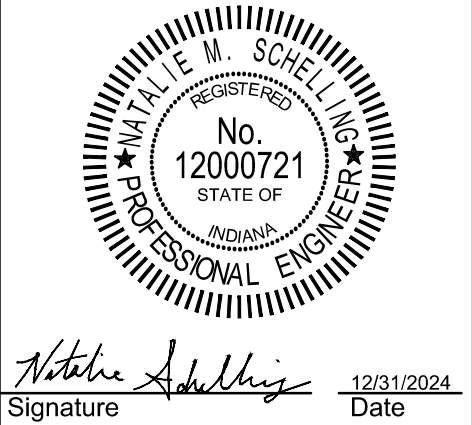

**TOWN OF CLAYPOOL
KOSCIUSKO COUNTY, INDIANA**

**CONTRACT C -
STORM SEWER
IMPROVEMENTS**

© 2024 BY COMMONWEALTH ENGINEERS, INC. ALL RIGHTS RESERVED. NO PART OF THIS DOCUMENT MAY BE REPRODUCED OR TRANSMITTED IN ANY FORM OR BY ANY MEANS, ELECTRONIC OR MECHANICAL, WITHOUT PERMISSION IN WRITING FROM COMMONWEALTH ENGINEERS, INC.
Indiana 811
Know what's below. 811 before you dig.
1-800-382-5544
(IT'S THE LAW)


No.	Submitted / Revision	By	Date

Designed By: BW	Drawn By: CH	Checked By: NS
Issue Date: 12/2024	Project No: S23130	Scale: AS SHOWN

**PLAN & PROFILE -
LINE 'A' - STATION
0+00-4+50**

Drawing No:
PP1

Sheet: 7 OF 21

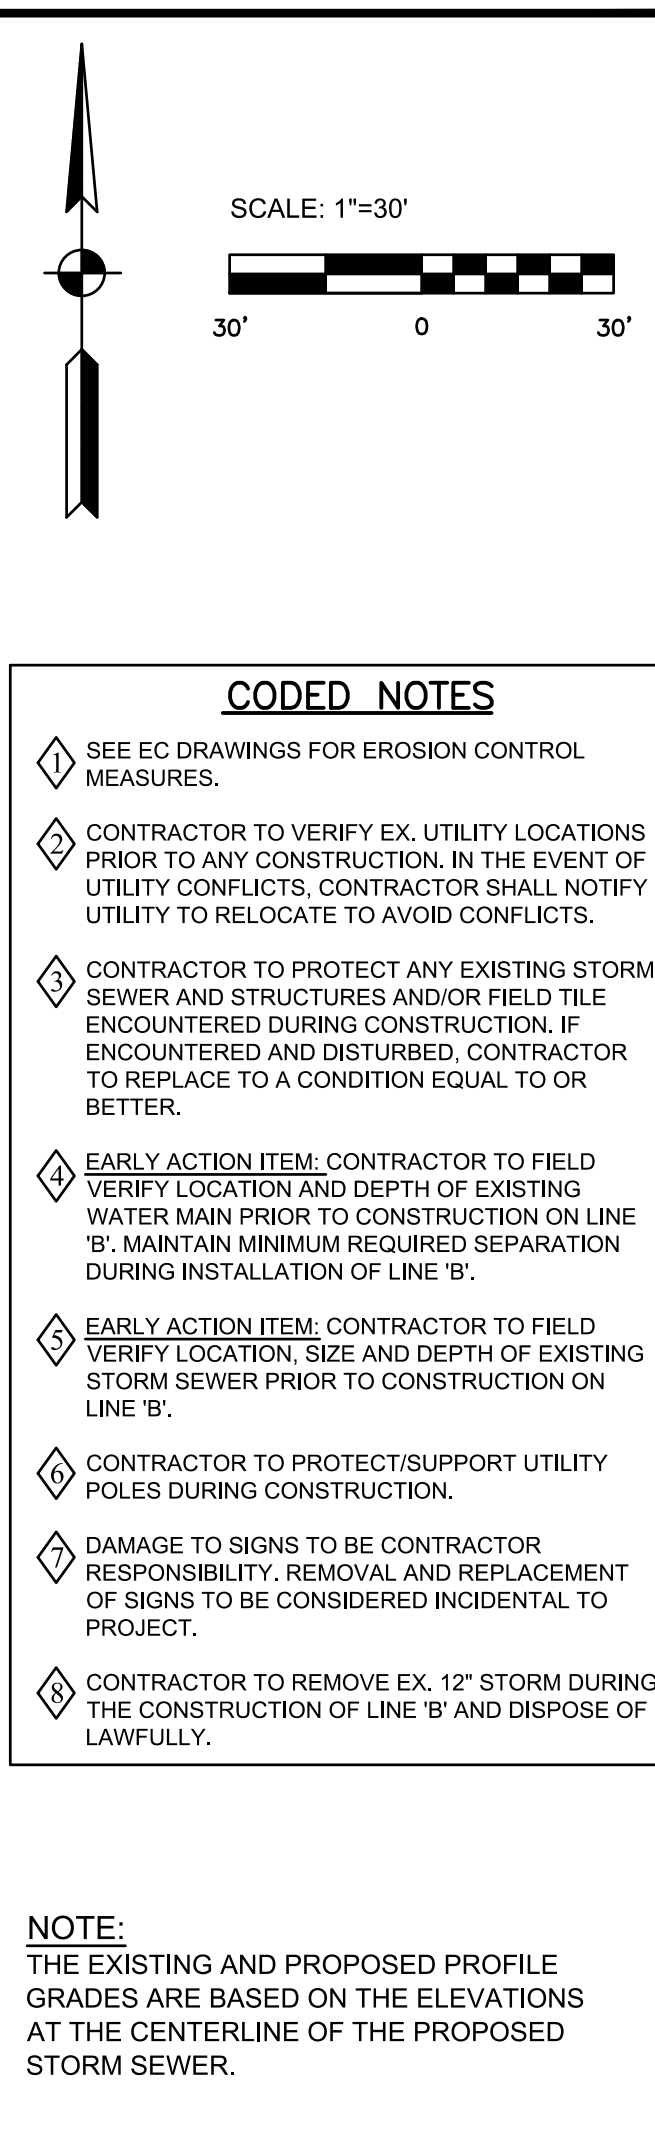

NOTE:
THE EXISTING AND PROPOSED PROFILE GRADES ARE BASED ON THE ELEVATIONS AT THE CENTERLINE OF THE PROPOSED STORM SEWER.




COMMONWEALTH[®]
ENGINEERS, INC.[®]

A wealth of resources to make a common good.

<http://commonwealthengineers.com/>

OFFICE LOCATIONS IN:

- INDIANAPOLIS, IN. (2)
- EVANSVILLE, IN.
- FORT WAYNE, IN.
- CROWN POINT, IN.
- BOWLING GREEN, KY.
- SOUTH BEND, IN.

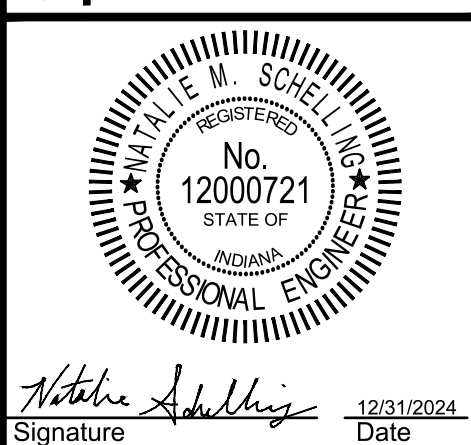

TOWN OF CLAYPOOL KOSCIUSKO COUNTY, INDIANA	CONTRACT C - STORM SEWER IMPROVEMENTS
--	---

© 2024 BY COMMONWEALTH
OF MASSACHUSETTS
RESERVED. REPRODUCTION BY
ANY METHOD IN WHOLE OR
IN PART WITHOUT PERMISSION
IS PROHIBITED

 **Indiana 811**
Know what's below.
Call before you dig.


Know what's below. 811 before you dig.
1-800-352-5544
(ITS THE LAW)


[illegible]

Designed By: BW	Drawn By: CH	Checked By: NS
Issue Date: 12/2024	Project No: S23130	Scale: AS SHOWN


PLAN & PROFILE -
LINE 'B' - STATION
0+00-3+42

Drawing No:
PP2
Sheet: 8 OF 21

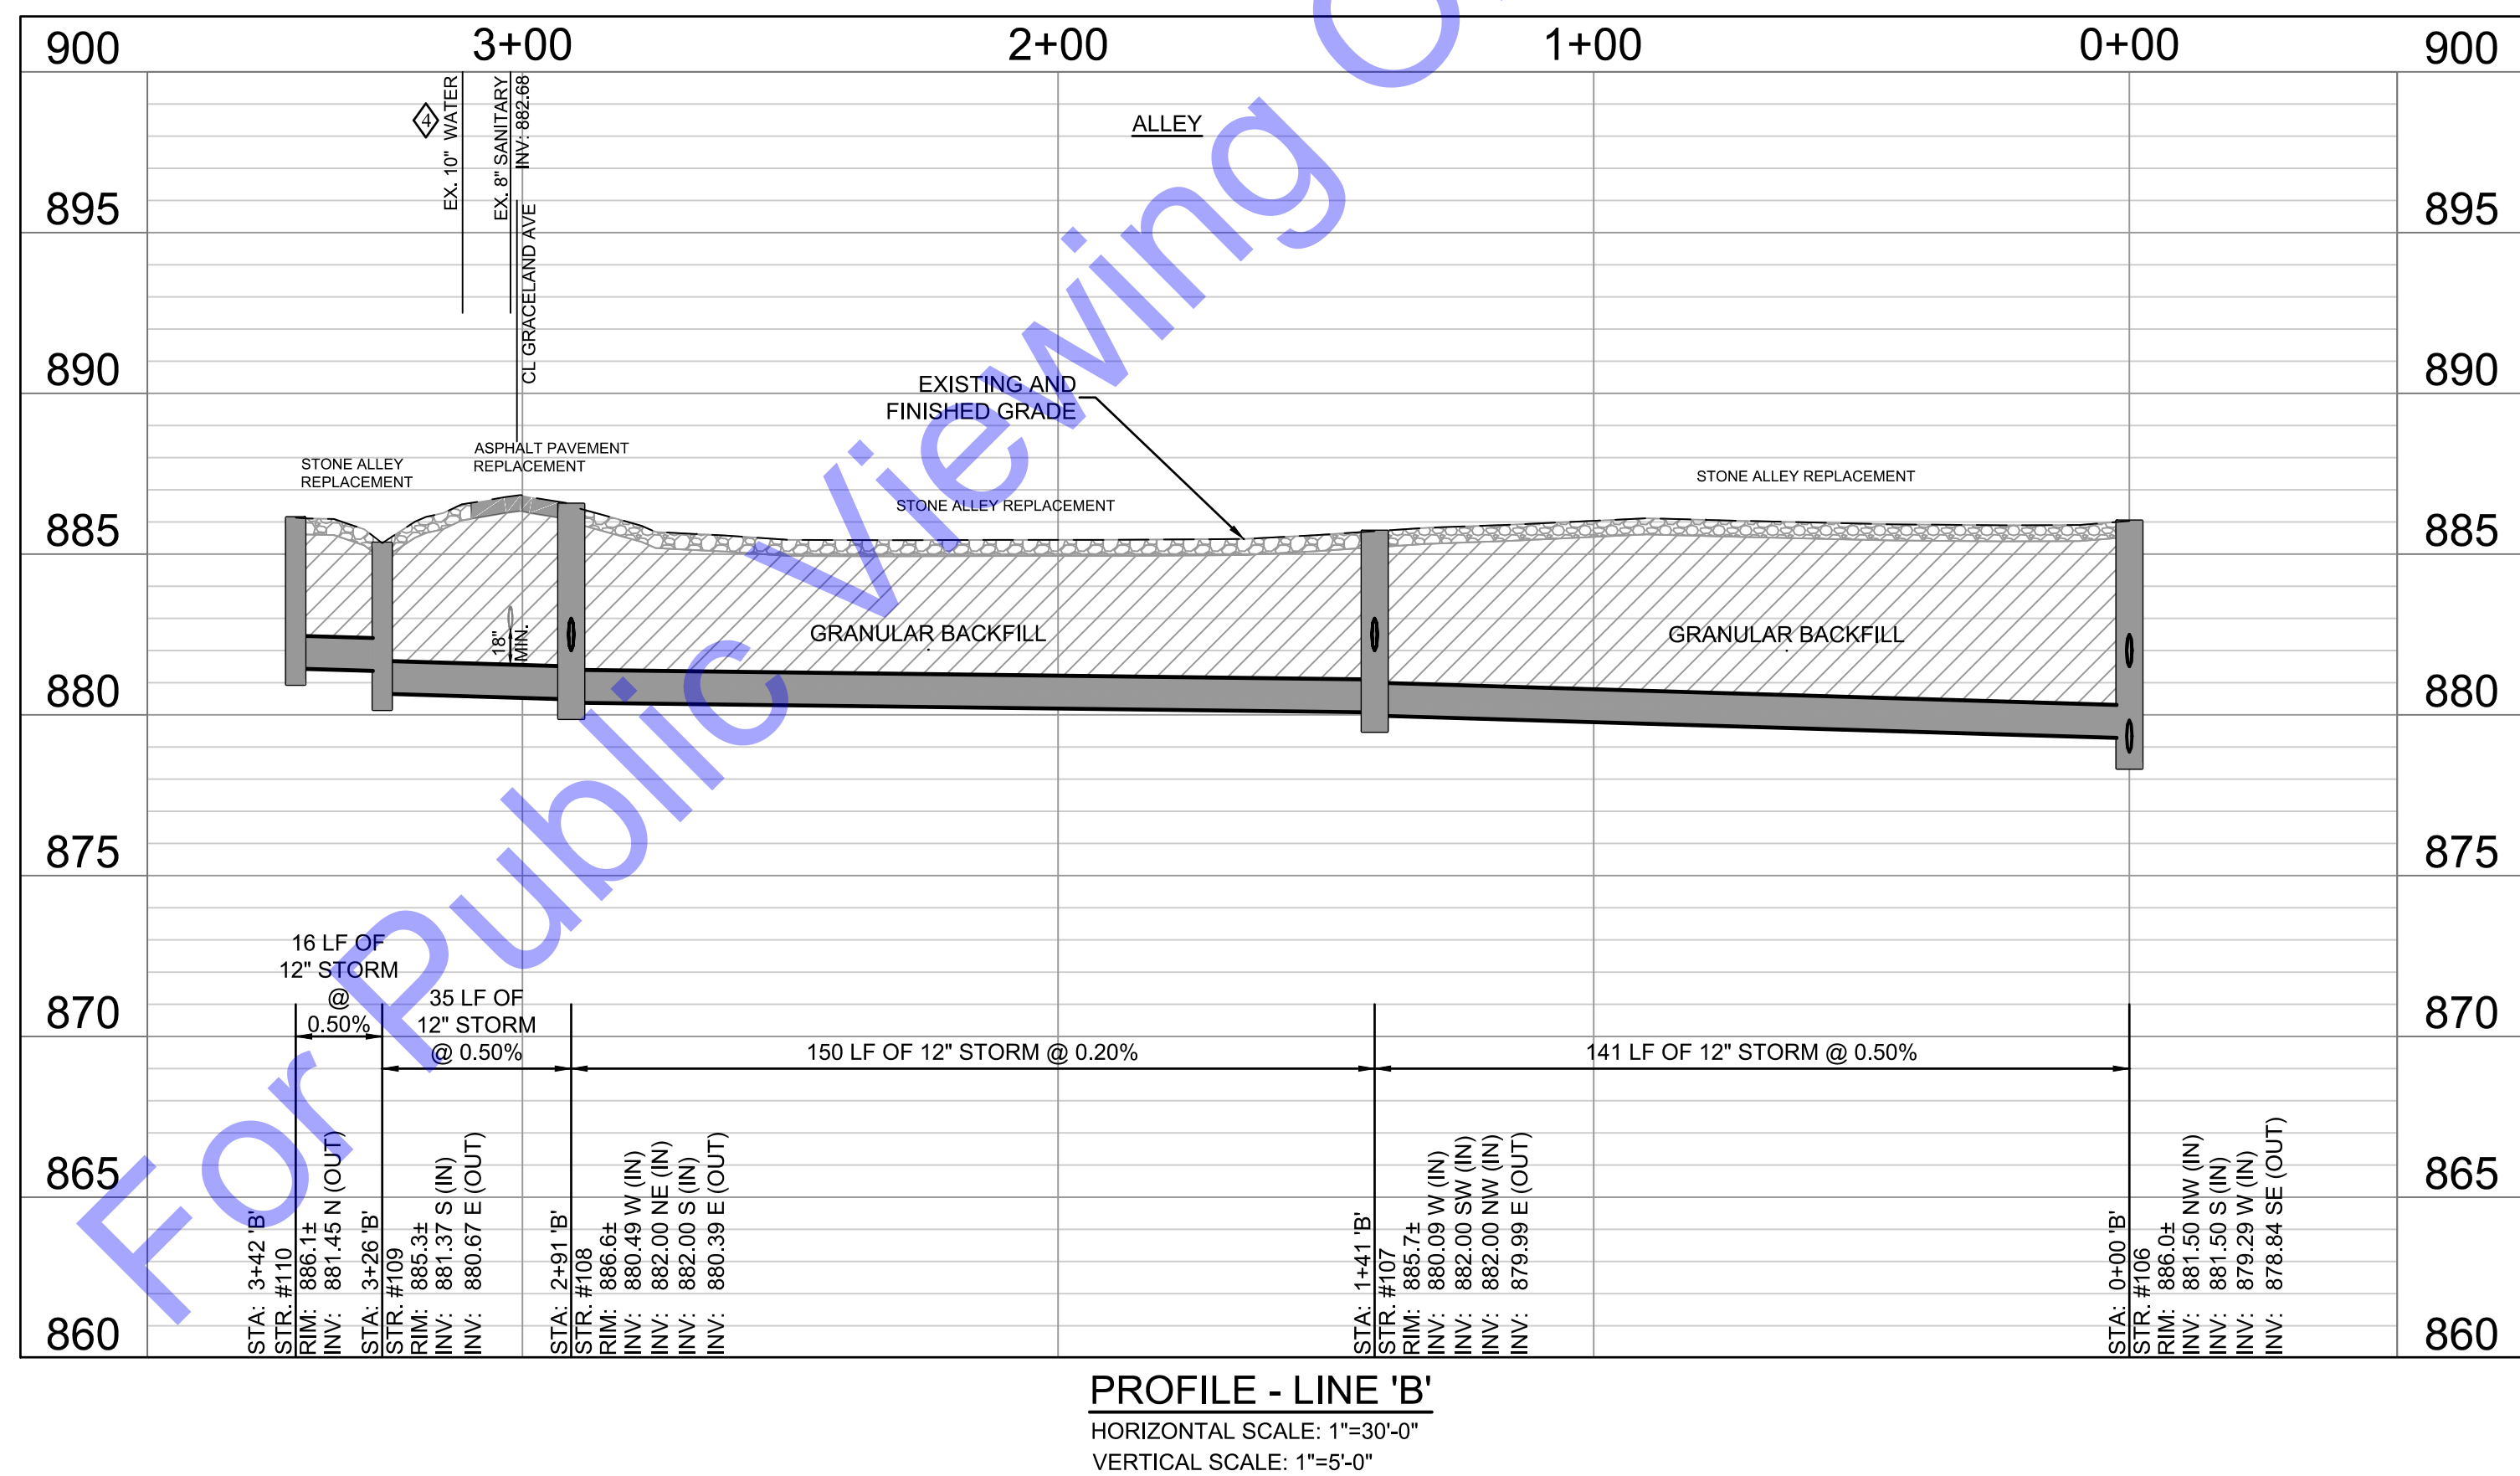

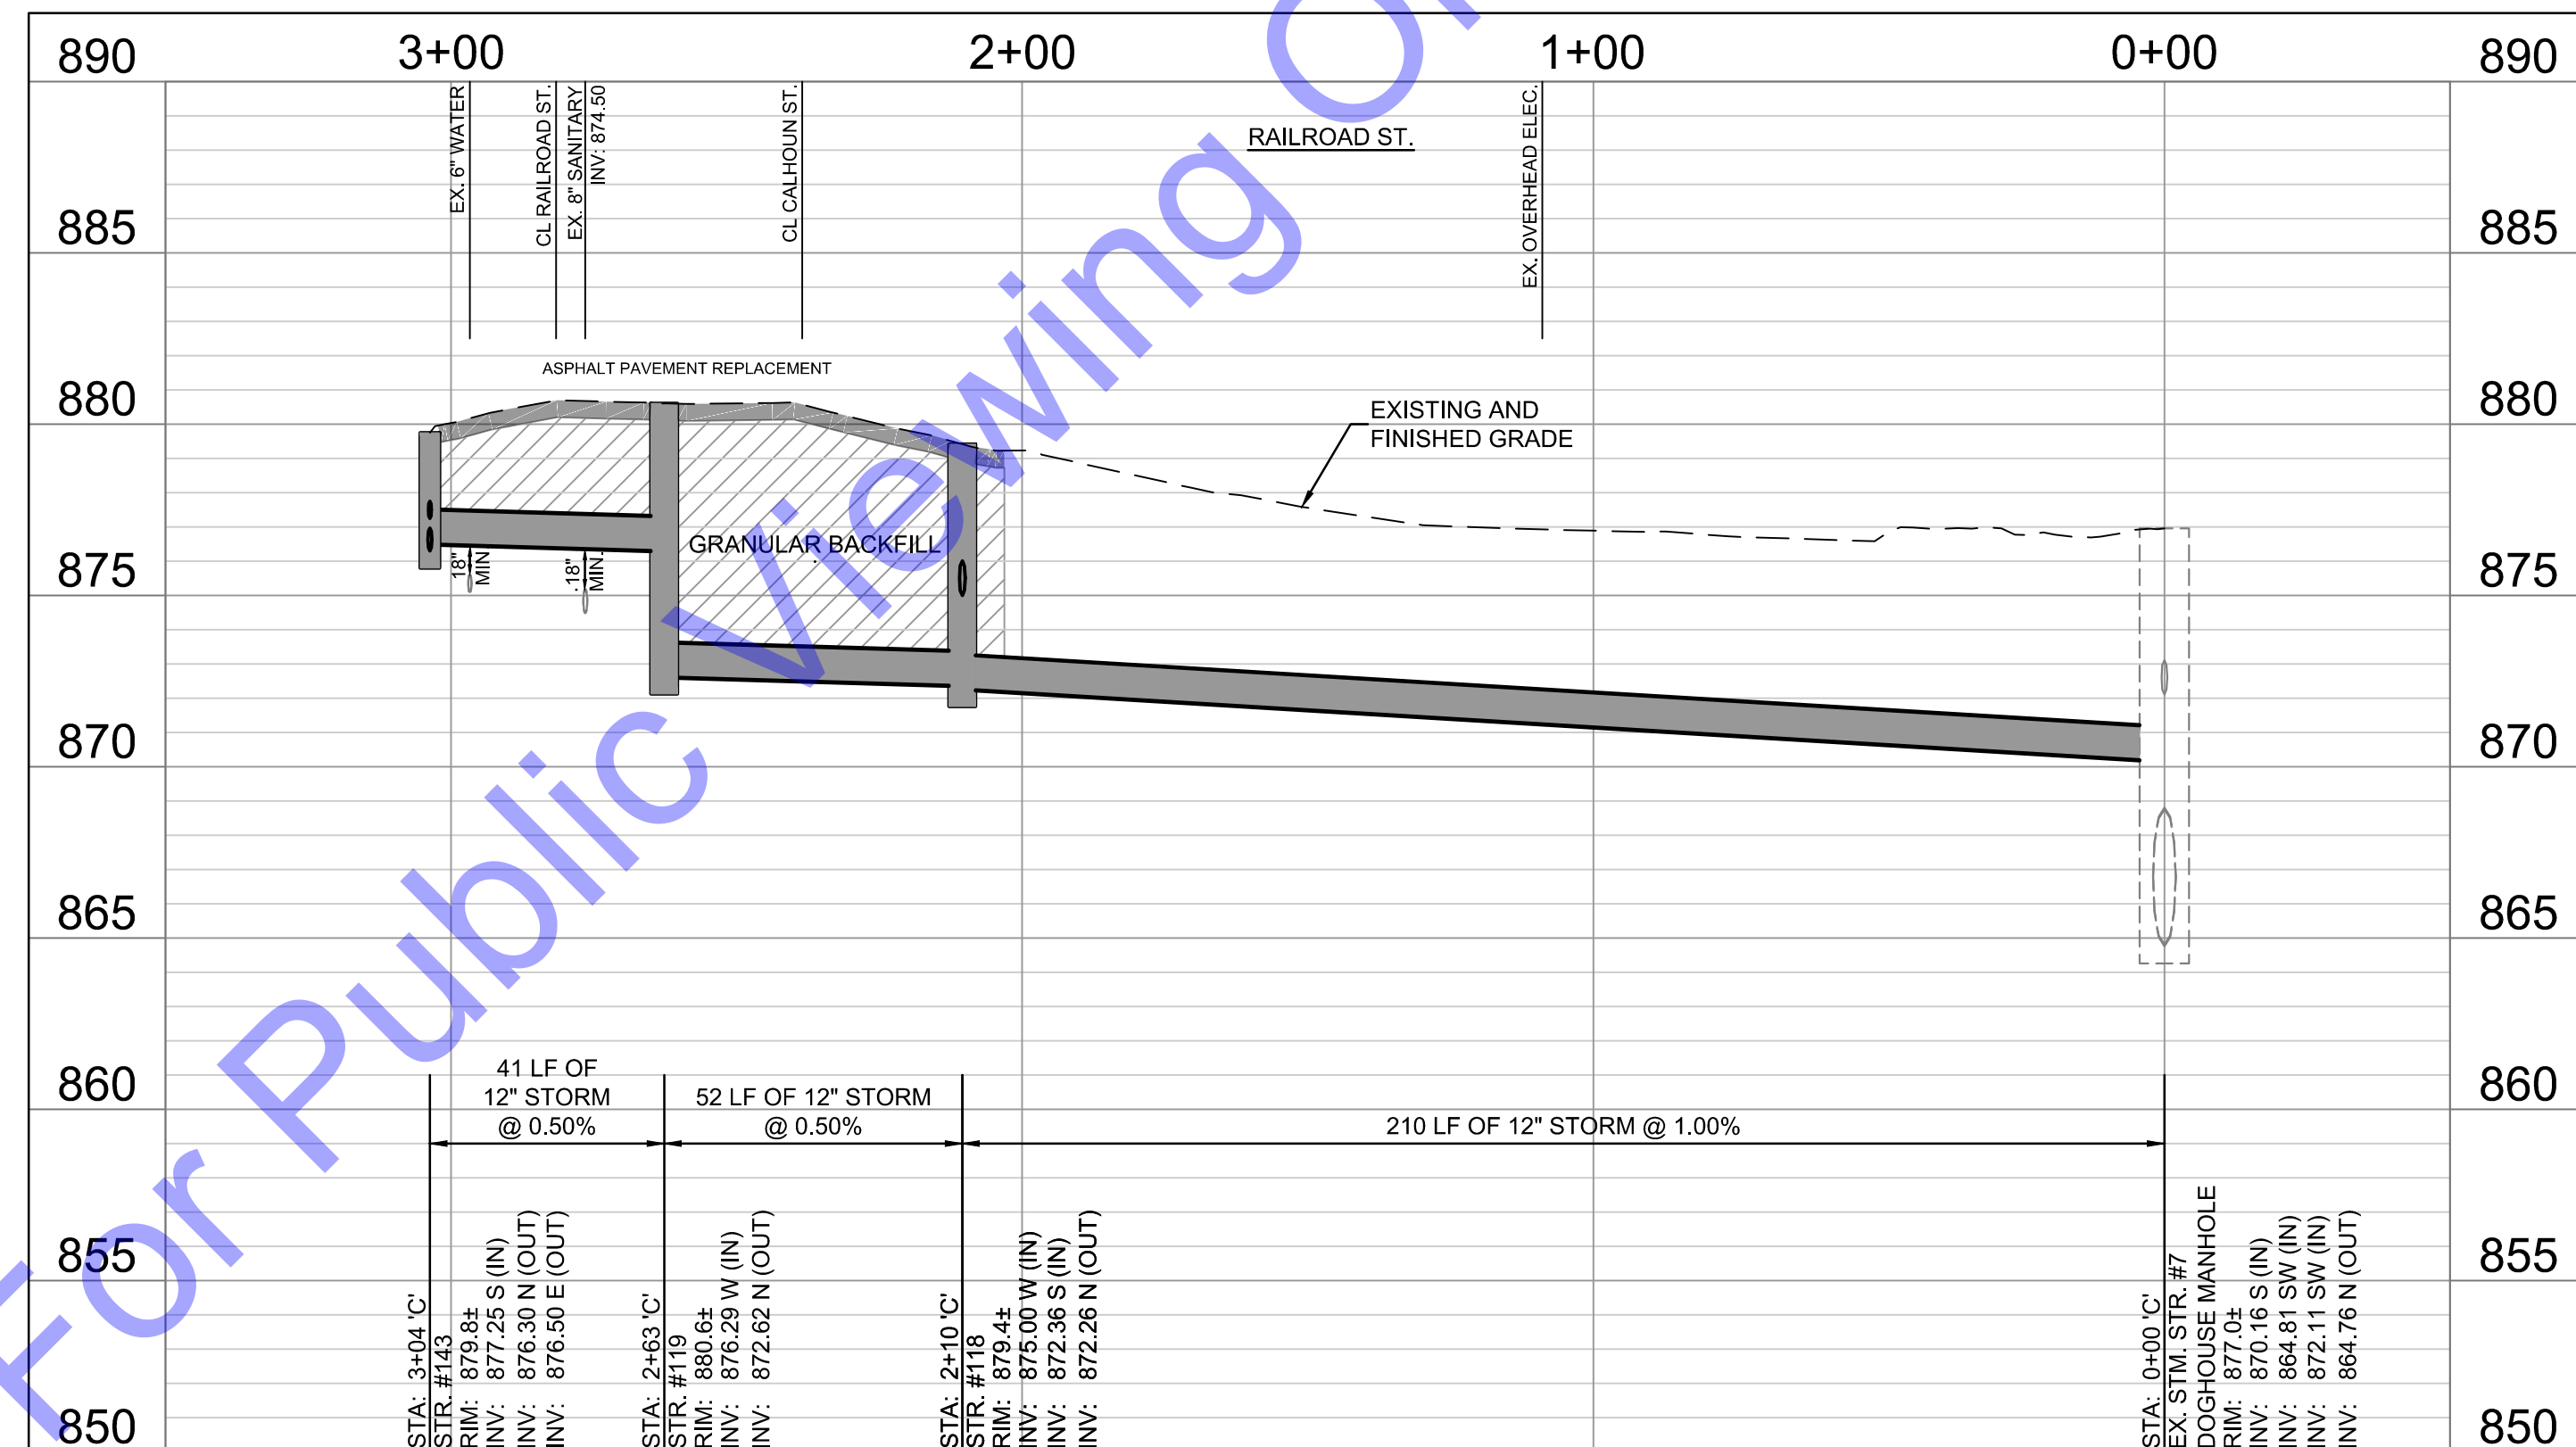


HORIZONTAL SCALE: 1"=30'-0"
VERTICAL SCALE: 1"=5'-0"

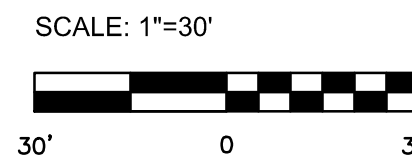


CODED NOTES

- ① SEE EC DRAWINGS FOR EROSION CONTROL MEASURES.
- ② CONTRACTOR TO VERIFY EX. UTILITY LOCATIONS PRIOR TO ANY CONSTRUCTION. IN THE EVENT OF UTILITY CONFLICTS, CONTRACTOR SHALL NOTIFY UTILITY TO RELOCATE TO AVOID CONFLICTS.
- ③ CONTRACTOR TO PROTECT ANY EXISTING STORM SEWER AND STRUCTURES AND/OR FIELD TILE ENCOUNTERED DURING CONSTRUCTION. IF ENCOUNTERED AND DISTURBED, CONTRACTOR TO REPLACE TO A CONDITION EQUAL TO OR BETTER.
- ④ EARLY ACTION ITEM: CONTRACTOR TO FIELD VERIFY LOCATION AND DEPTH OF EXISTING WATER MAIN PRIOR TO CONSTRUCTION ON LINE 'C'. MAINTAIN MINIMUM REQUIRED SEPARATION DURING INSTALLATION OF LINE 'C'.
- ⑤ EARLY ACTION ITEM: CONTRACTOR TO FIELD VERIFY LOCATION, SIZE AND DEPTH OF EXISTING 48" STORM SEWER PRIOR TO CONSTRUCTION ON LINE 'C'.
- ⑥ CONTRACTOR TO PROTECT/SUPPORT UTILITY POLES DURING CONSTRUCTION.
- ⑦ DAMAGE TO SIGNS TO BE CONTRACTOR RESPONSIBILITY. REMOVAL AND REPLACEMENT OF SIGNS TO BE CONSIDERED INCIDENTAL TO PROJECT.

NOTE:
THE EXISTING AND PROPOSED PROFILE GRADES ARE BASED ON THE ELEVATIONS AT THE CENTERLINE OF THE PROPOSED SANITARY SEWER.

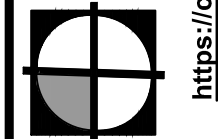

COMMONWEALTHTM
ENGINEERS, INC.
A wealth of resources to master a common goal.
commonwealthengineers.com/

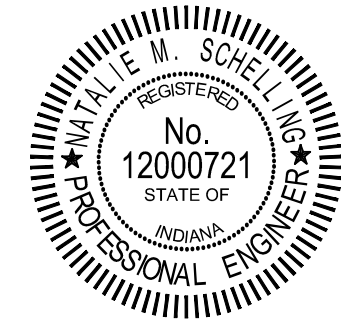


Signature Natalie Schelling Date 12/31/2024

**TOWN OF CLAYPOOL
KOSCIUSKO COUNTY, INDIANA**

**CONTRACT C -
STORM SEWER
IMPROVEMENTS**

© 2024 BY COMMONWEALTH
ENGINEERS, INC. ALL RIGHTS
RESERVED. REPRODUCTION BY
ANY METHOD IN WHOLE OR
IN PART WITHOUT PERMISSION
IS PROHIBITED

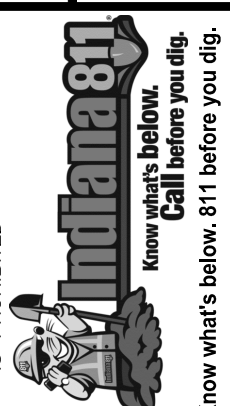

1-800-382-5544
(ITS THE LAW)

[illegible]

Designed By: BW	Drawn By: CH	Checked By: NS
--------------------	-----------------	-------------------



Issue Date: 12/2024	Project No: S23130	Scale: AS SHOWN
------------------------	-----------------------	--------------------

PLAN & PROFILE -
LINE 'C' - STATION
0+00-3+04

Drawing No:

PP3

Sheet: 9 OF 21

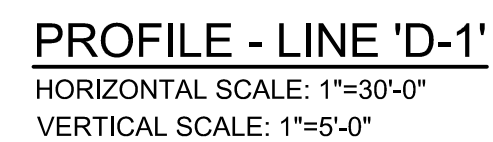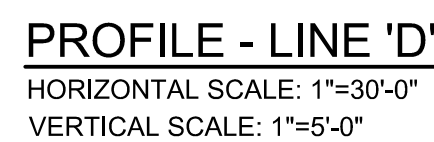

NOTE:
THE EXISTING AND PROPOSED PROFILE GRADES ARE BASED ON THE ELEVATIONS AT THE CENTERLINE OF THE PROPOSED SANITARY SEWER.



Signature Nate Schelling Date 12/31/2024

© 2024 BY COMMONWEALTH ENGINEERS, INC. ALL RIGHTS RESERVED. REPRODUCTION BY ANY METHOD IN WHOLE OR IN PART WITHOUT PERMISSION IS PROHIBITED




Know what's below.
Call before you dig.

Know what's below. 811 before you dig.


1-800-382-5544
(IT'S THE LAW)

Designed By: BW	Drawn By: CH	Checked By: NS
Issue Date: 12/2024	Project No: S23130	Scale: AS SHOWN


Drawing No:
PP4
Sheet: 10 OF 21

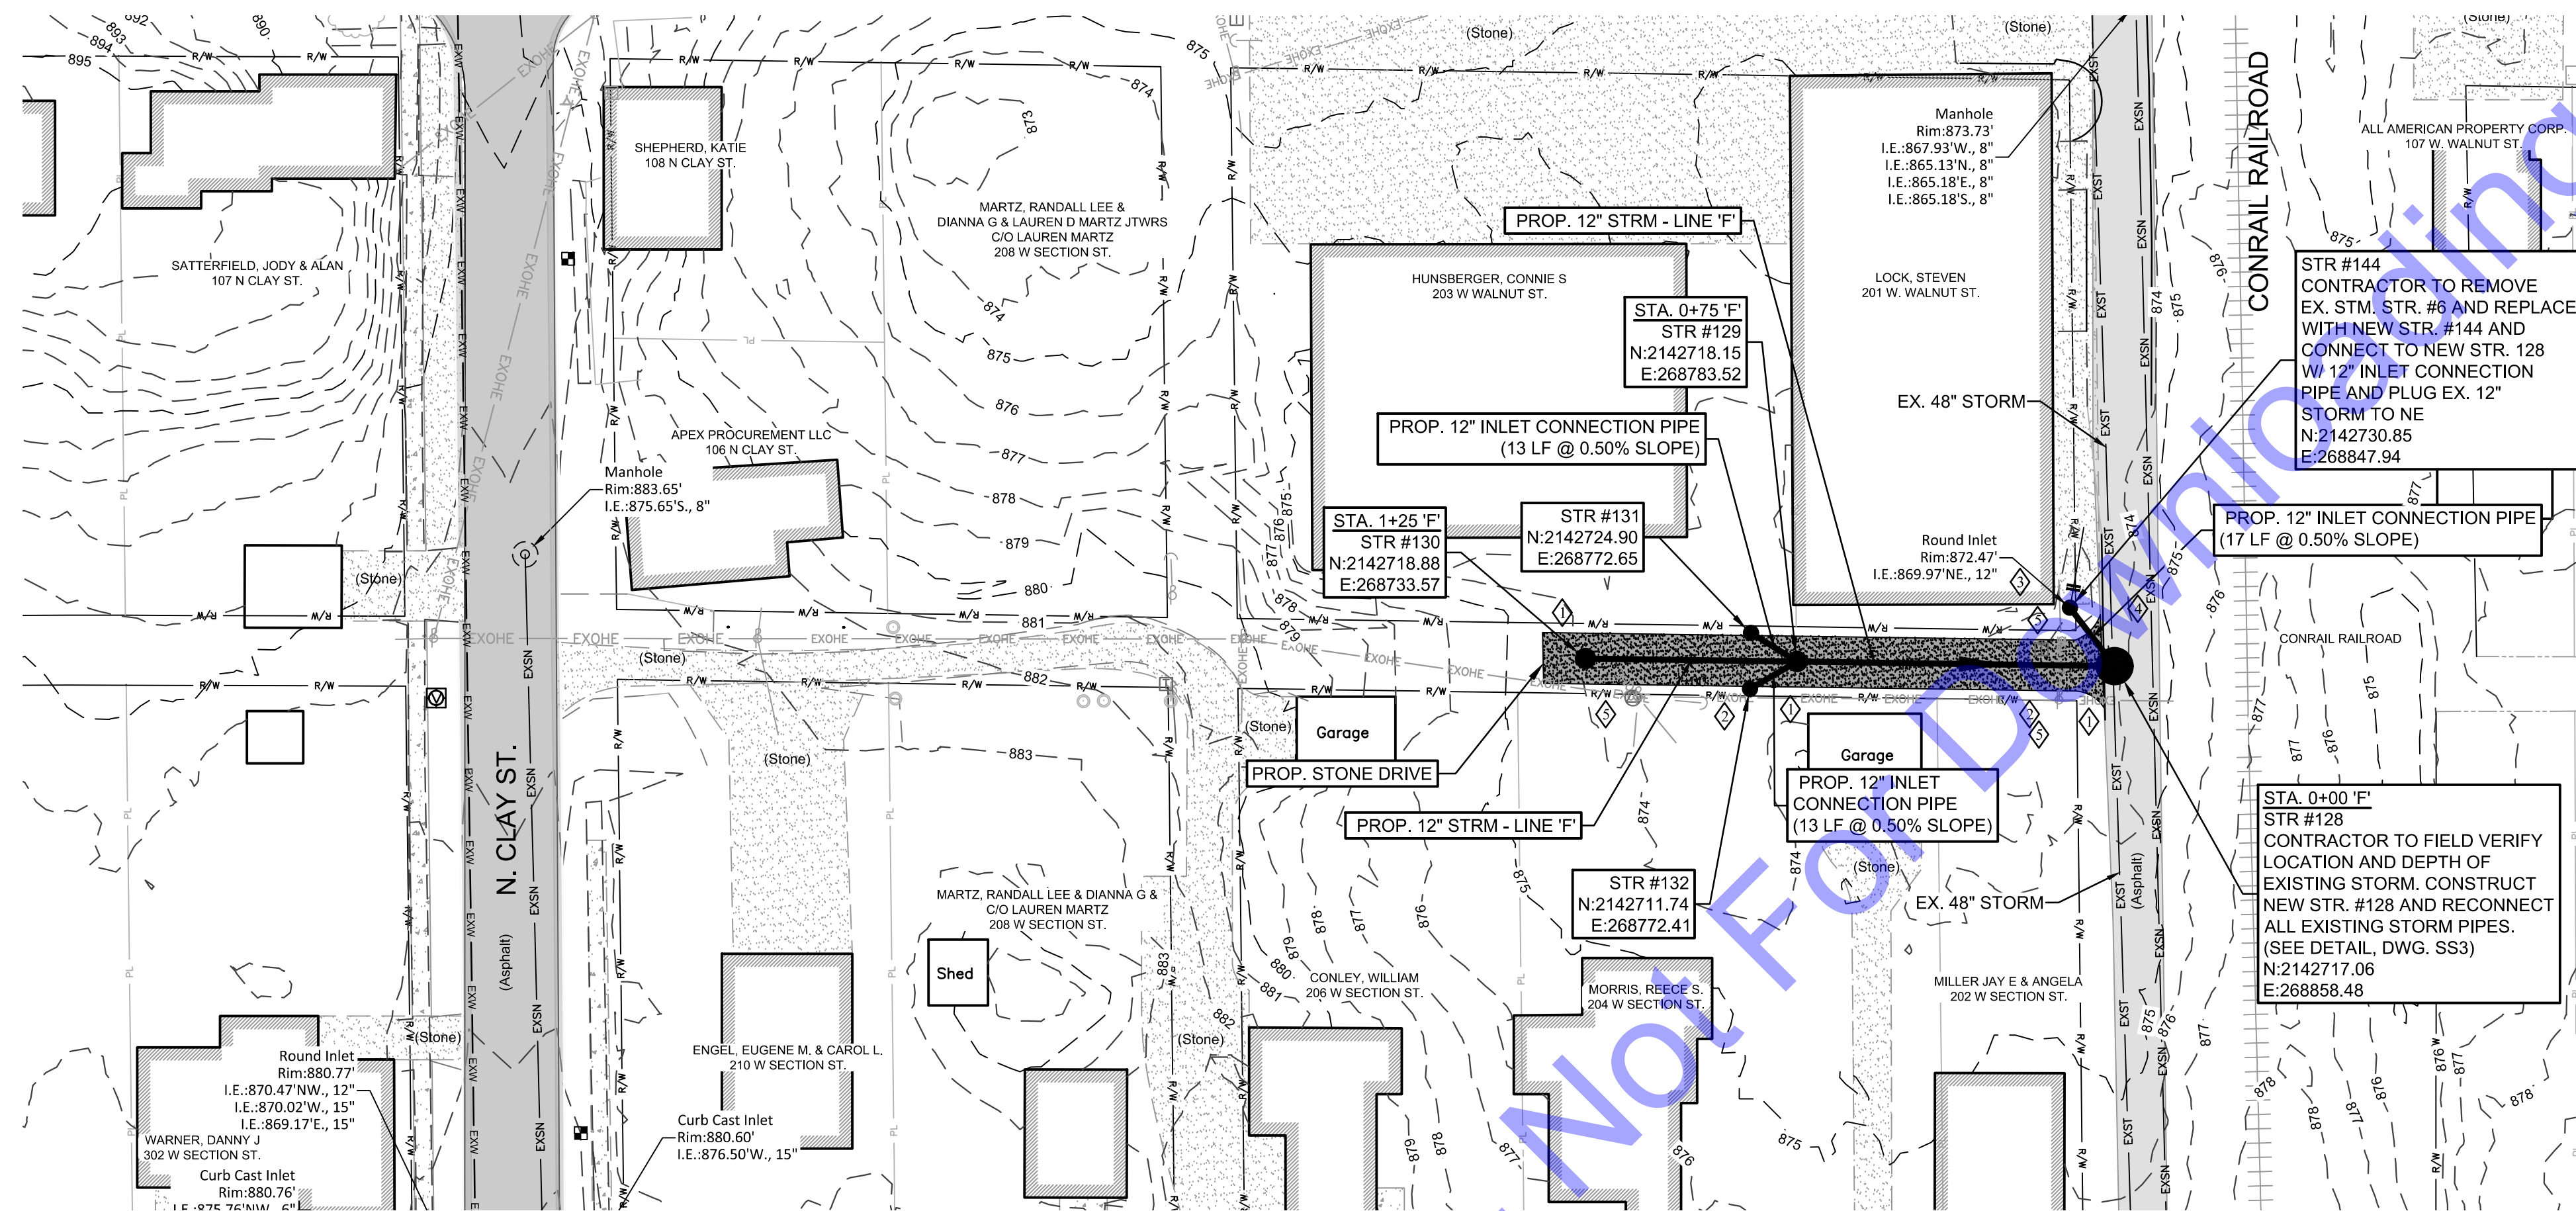


PLAN VIEW
SCALE: 1"=30'-0"

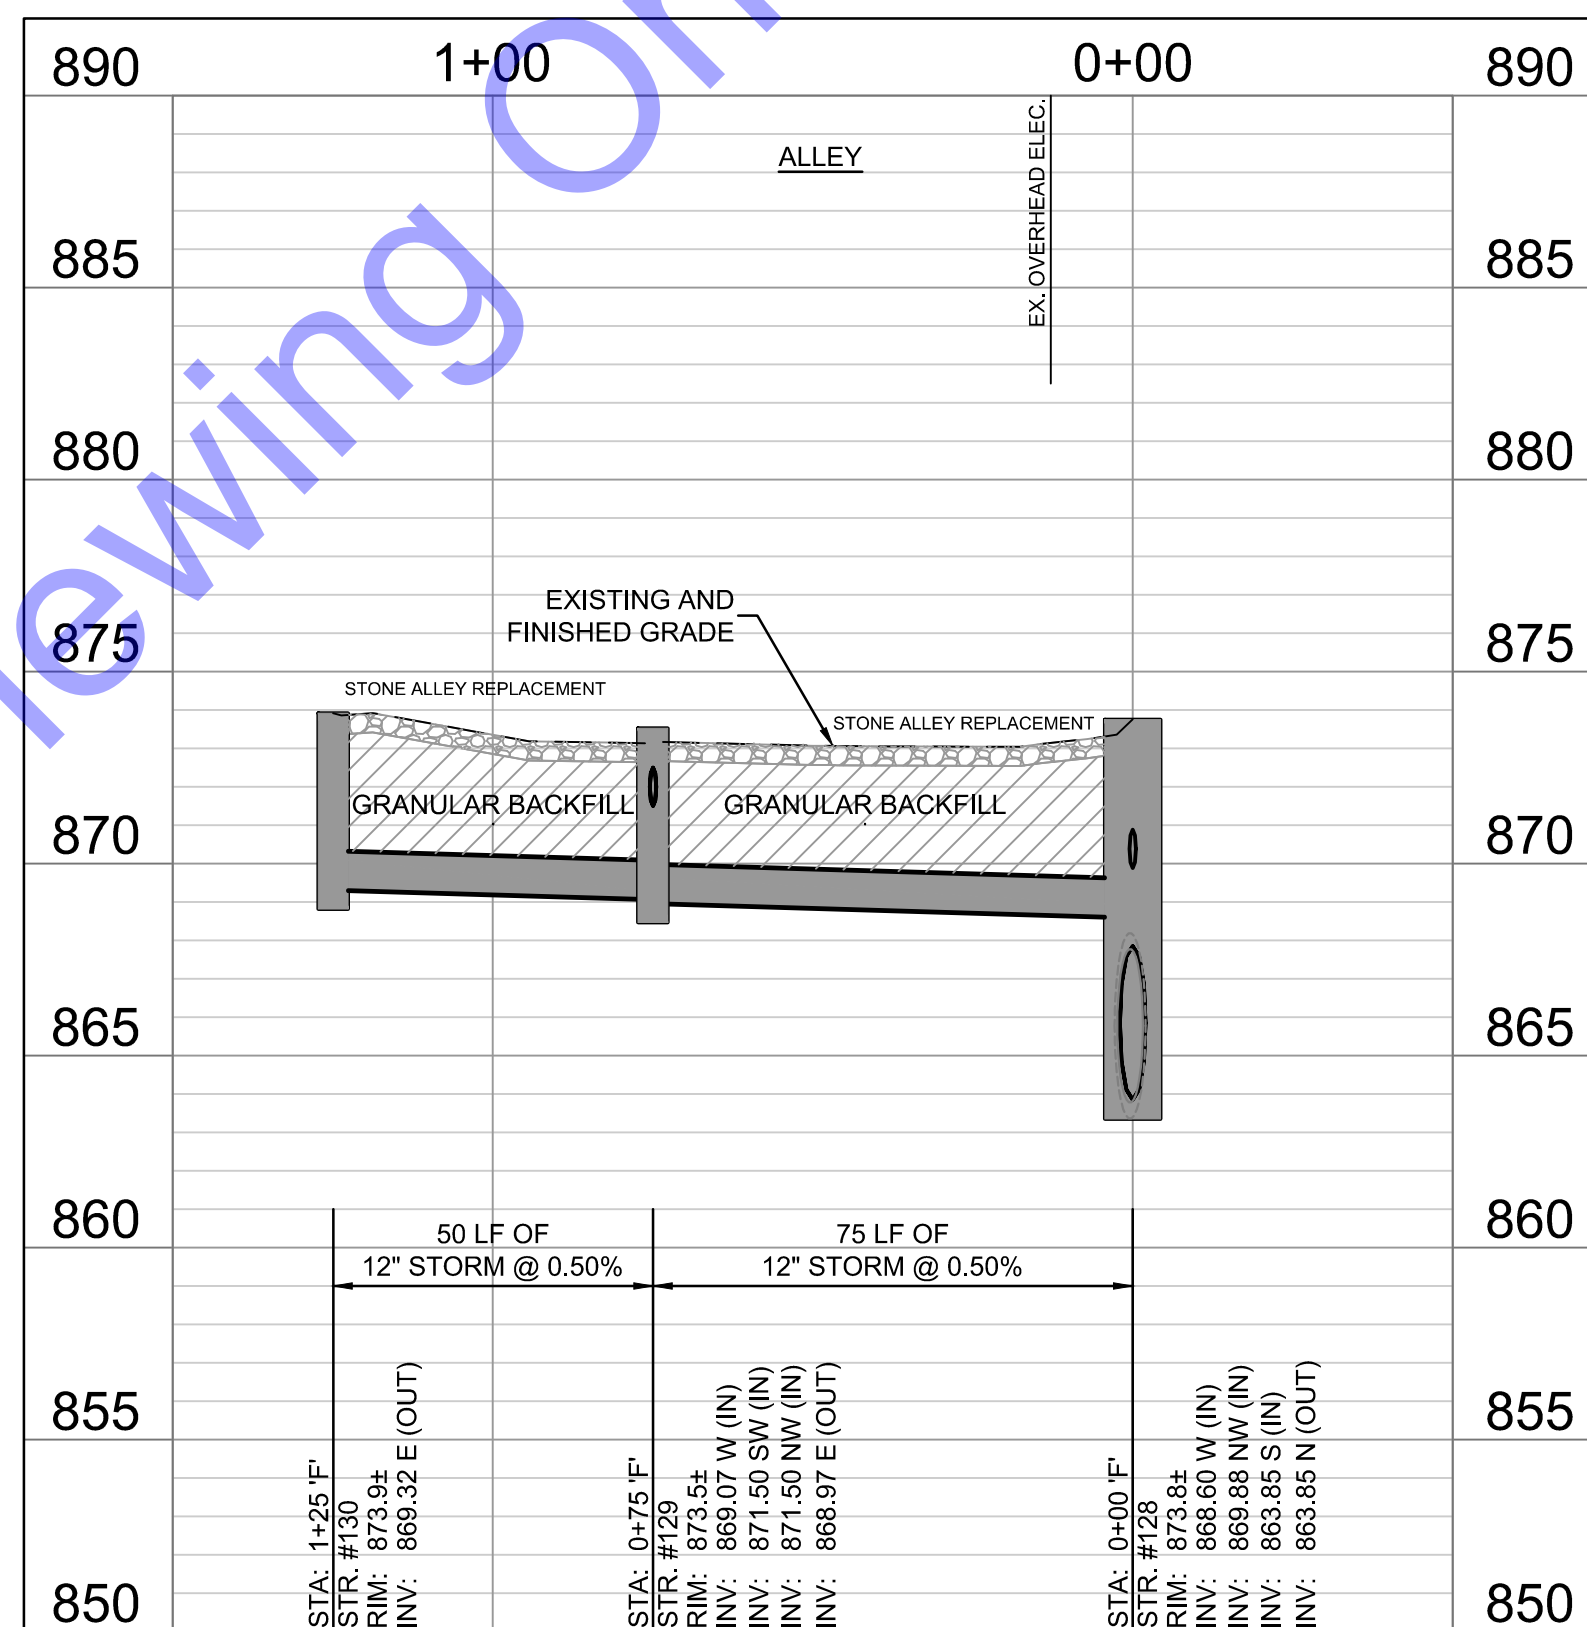

PROFILE - LINE 'F'
HORIZONTAL SCALE: 1"=30'-0"
VERTICAL SCALE: 1"=5'-0"

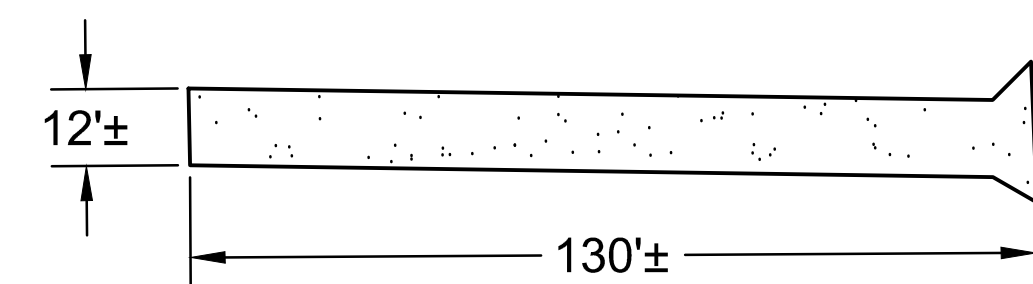

STONE ALLEY PLAN LAYOUT
SCALE: NONE

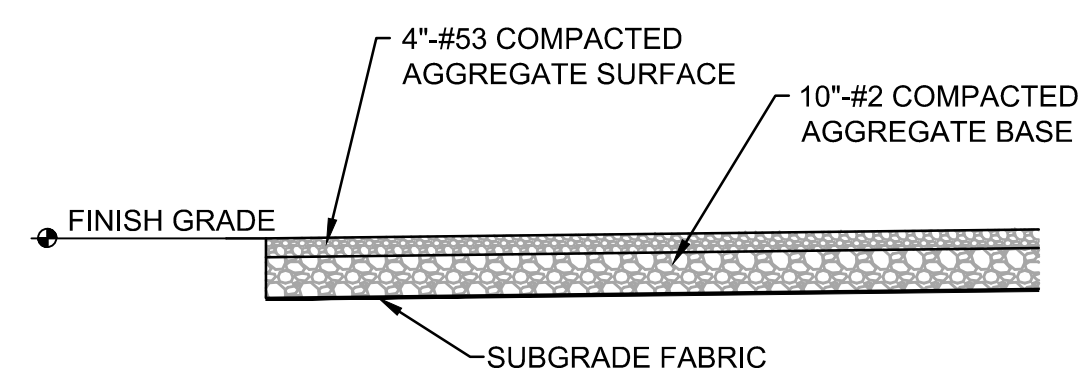

STONE SITE
NO SCALE

NOTE:
THE EXISTING AND PROPOSED PROFILE GRADES ARE BASED ON THE ELEVATIONS AT THE CENTERLINE OF THE PROPOSED SANITARY SEWER.

CODED NOTES

- 1 SEE EC DRAWINGS FOR EROSION CONTROL MEASURES.
- 2 CONTRACTOR TO VERIFY EX. UTILITY LOCATIONS PRIOR TO ANY CONSTRUCTION. IN THE EVENT OF UTILITY CONFLICTS, CONTRACTOR SHALL NOTIFY UTILITY TO RELOCATE TO AVOID CONFLICTS.
- 3 CONTRACTOR TO PROTECT ANY EXISTING STORM SEWER AND STRUCTURES AND/OR FIELD TILE ENCOUNTERED DURING CONSTRUCTION. IF ENCOUNTERED AND DISTURBED, CONTRACTOR TO REPLACE TO A CONDITION EQUAL TO OR BETTER.
- 4 **EARLY ACTION ITEM:** CONTRACTOR TO FIELD VERIFY LOCATION, SIZE AND DEPTH OF EXISTING 48" STORM SEWER PRIOR TO CONSTRUCTION ON LINE 'F'.
- 5 CONTRACTOR TO PROTECT/SUPPORT UTILITY POLES DURING CONSTRUCTION.



**COMMONWEALTHTM
ENGINEERS, INC.[®]**

A wealth of resources to resolve a common goal.

<http://www.commonwealthengineers.com/>

OFFICE LOCATIONS IN:

- INDIANAPOLIS, IN. (2)
- EVANSVILLE, IN.
- FORT WAYNE, IN.
- CROWN POINT, IN.
- BOWLING GREEN, KY.
- SOUTH BEND, IN.



Natalie M. Schelling
REGISTERED
No. 12000721
STATE OF INDIANA
PROFESSIONAL ENGINEER

Natalie Schelling
Signature

12/31/2024
Date

**TOWN OF CLAYPOOL
KOSCIUSKO COUNTY, INDIANA**

**CONTRACT C -
STORM SEWER
IMPROVEMENTS**

© 2024 BY COMMONWEALTH ENGINEERS, INC. ALL RIGHTS RESERVED. REPRODUCTION BY ANY METHOD IN WHOLE OR IN PART WITHOUT PERMISSION IS PROHIBITED.

 **Indiana 811**

Know what's below.
Call before you dig.

Know what's below. 811 before you dig.
1-800-382-5544
(IT'S THE LAW)


 
[illegible]

Designed By: BW	Drawn By: CH	Checked By: NS
Issue Date: 12/2024	Project No: S23130	Scale: AS SHOWN

PLAN & PROFILE -
LINE 'F' - STATION
0+00-1+25

Drawing No:
PP5

Sheet: 11 OF 21

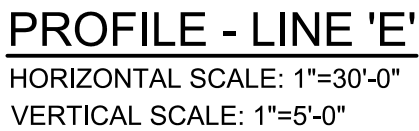

- 1 SEE EC DRAWINGS FOR EROSION CONTROL MEASURES.
- 2 CONTRACTOR TO VERIFY EX. UTILITY LOCATIONS PRIOR TO ANY CONSTRUCTION. IN THE EVENT OF UTILITY CONFLICTS, CONTRACTOR SHALL NOTIFY UTILITY TO RELOCATE TO AVOID CONFLICTS.
- 3 CONTRACTOR TO PROTECT ANY EXISTING STORM SEWER AND STRUCTURES AND/OR FIELD TILE ENCOUNTERED DURING CONSTRUCTION. IF ENCOUNTERED AND DISTURBED, CONTRACTOR TO REPLACE TO A CONDITION EQUAL TO OR BETTER.
- 4 **EARLY ACTION ITEM:** CONTRACTOR TO FIELD VERIFY LOCATION AND DEPTH OF EXISTING STORM SEWER PRIOR TO CONSTRUCTION ON LINE 'E'. MAINTAIN MINIMUM REQUIRED SEPARATION DURING INSTALLATION OF LINE 'E'.
- 5 **EARLY ACTION ITEM:** CONTRACTOR TO FIELD VERIFY LOCATION, SIZE AND DEPTH OF EXISTING STORM SEWER PRIOR TO CONSTRUCTION ON LINE 'E'.
- 6 CONTRACTOR TO PROTECT/SUPPORT UTILITY POLES DURING CONSTRUCTION.

PLAN & PROFILE -
LINE 'E' - STATION
0+00-3+55

PP6

Sheet: 12 OF 21

CONTRACT C - STORM SEWER IMPROVEMENTS


© 2024 BY COMMONWEALTH ENGINEERS, INC. ALL RIGHTS RESERVED. REPRODUCTION BY ANY METHOD IN WHOLE OR IN PART WITHOUT PERMISSION IS PROHIBITED




Know what's below.
Call before you dig.

Know what's below. 811 before you dig


1-800-382-5544
(ITS THE LAW)

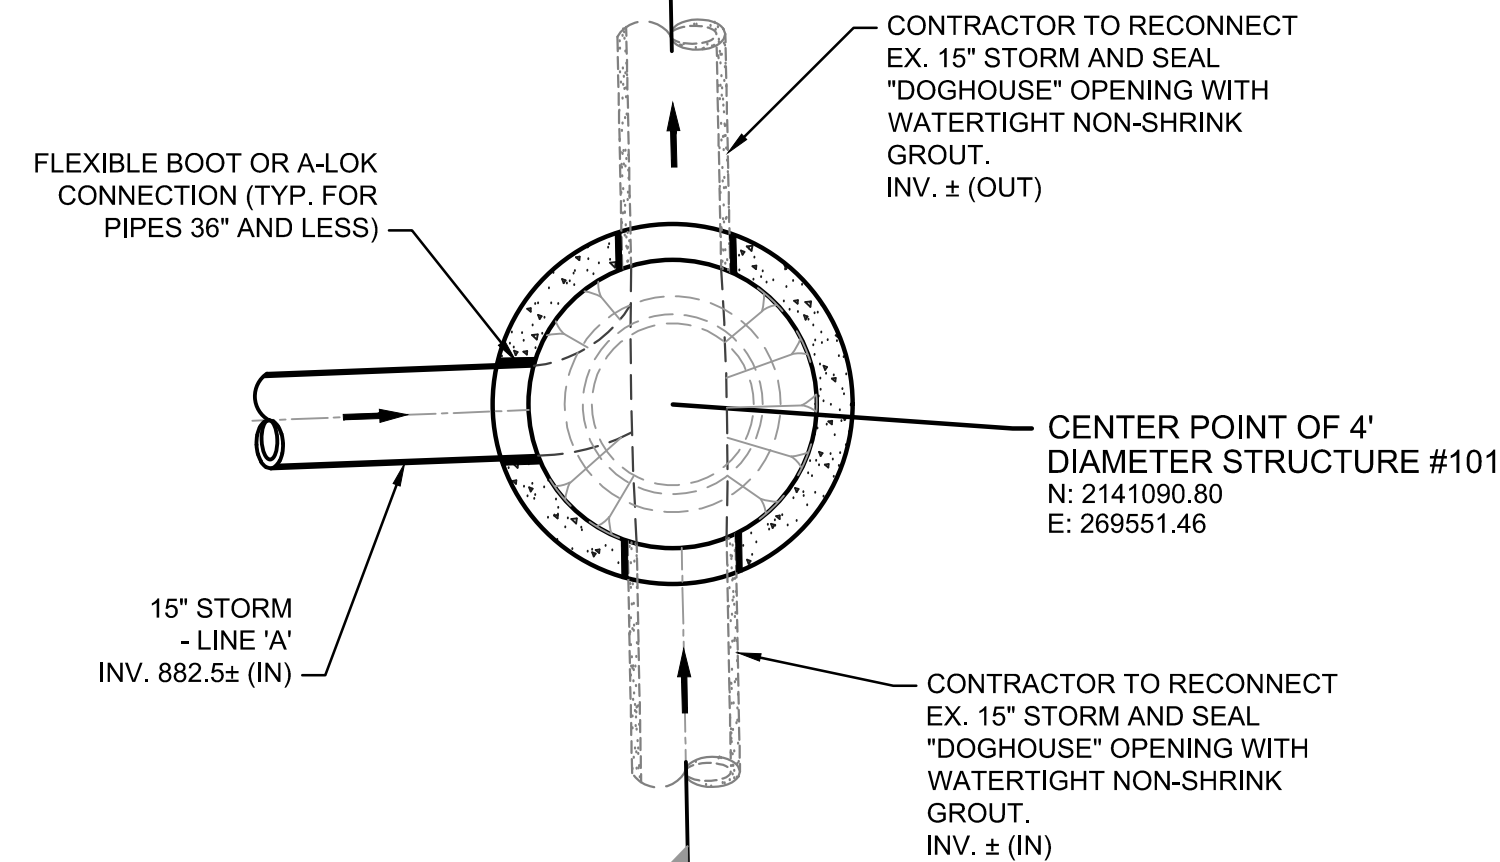


PLAN VIEW
(SEE DWG.PP1)

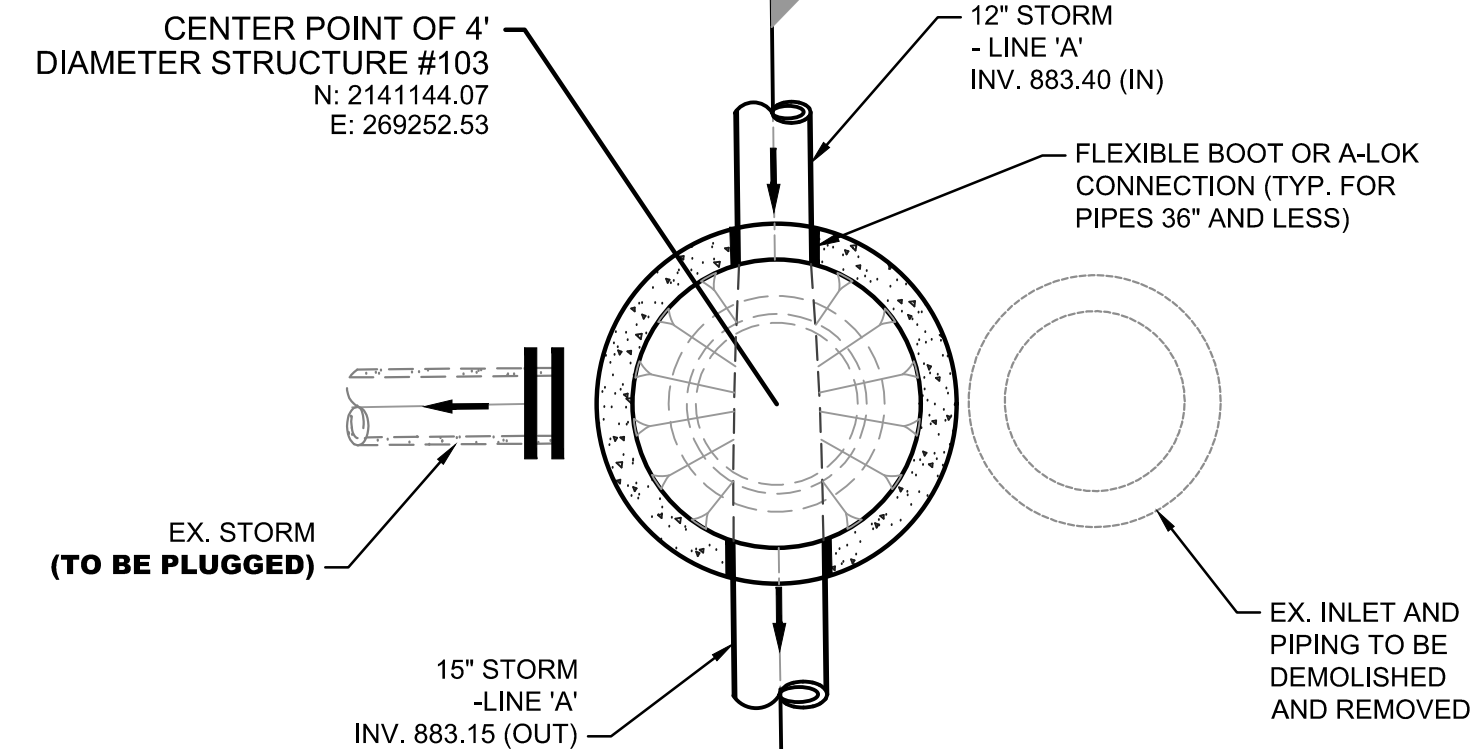


PLAN VIEW
(SEE DWG.PP1)

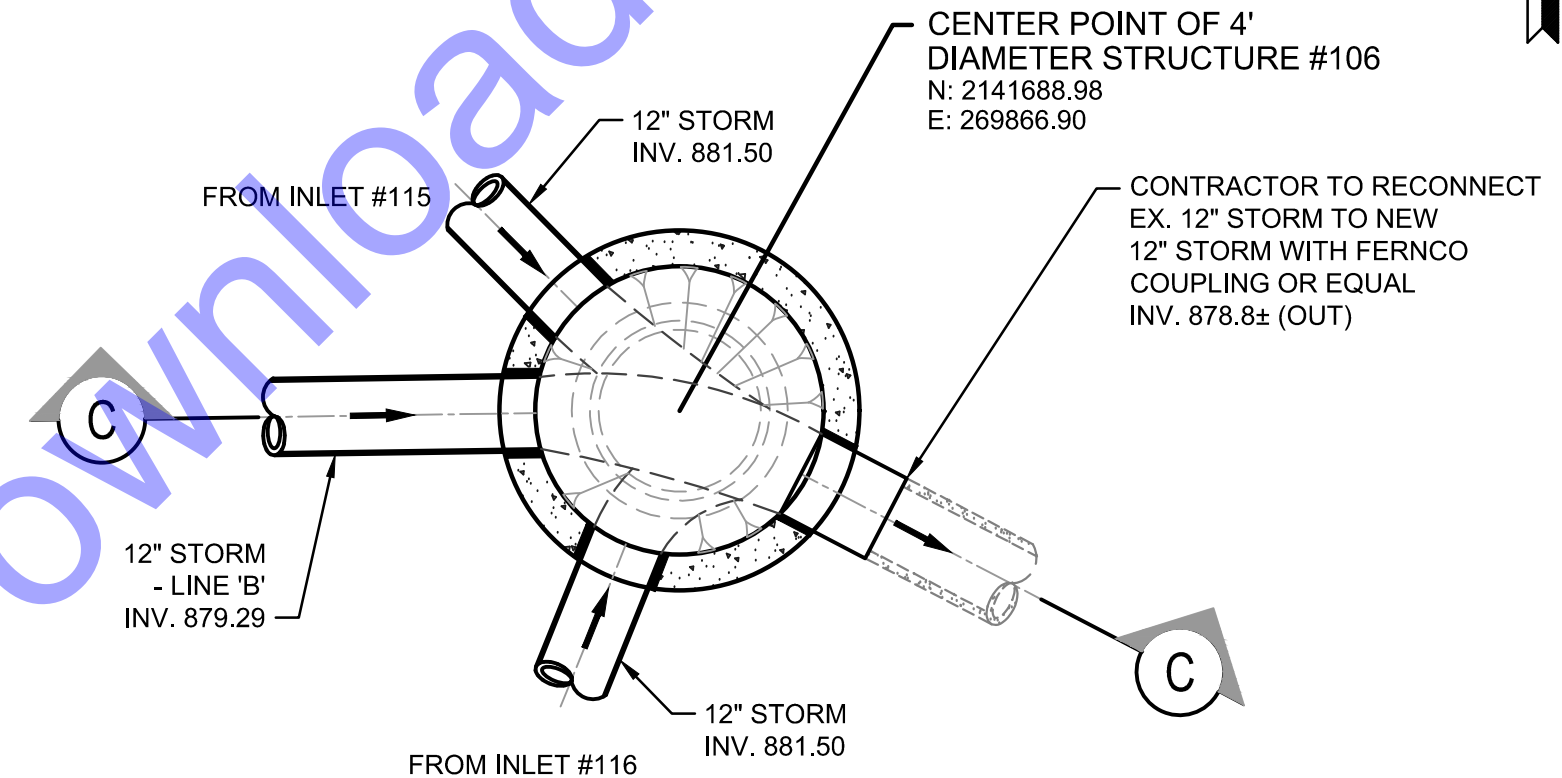


PLAN VIEW
(SEE DWG. PP2)

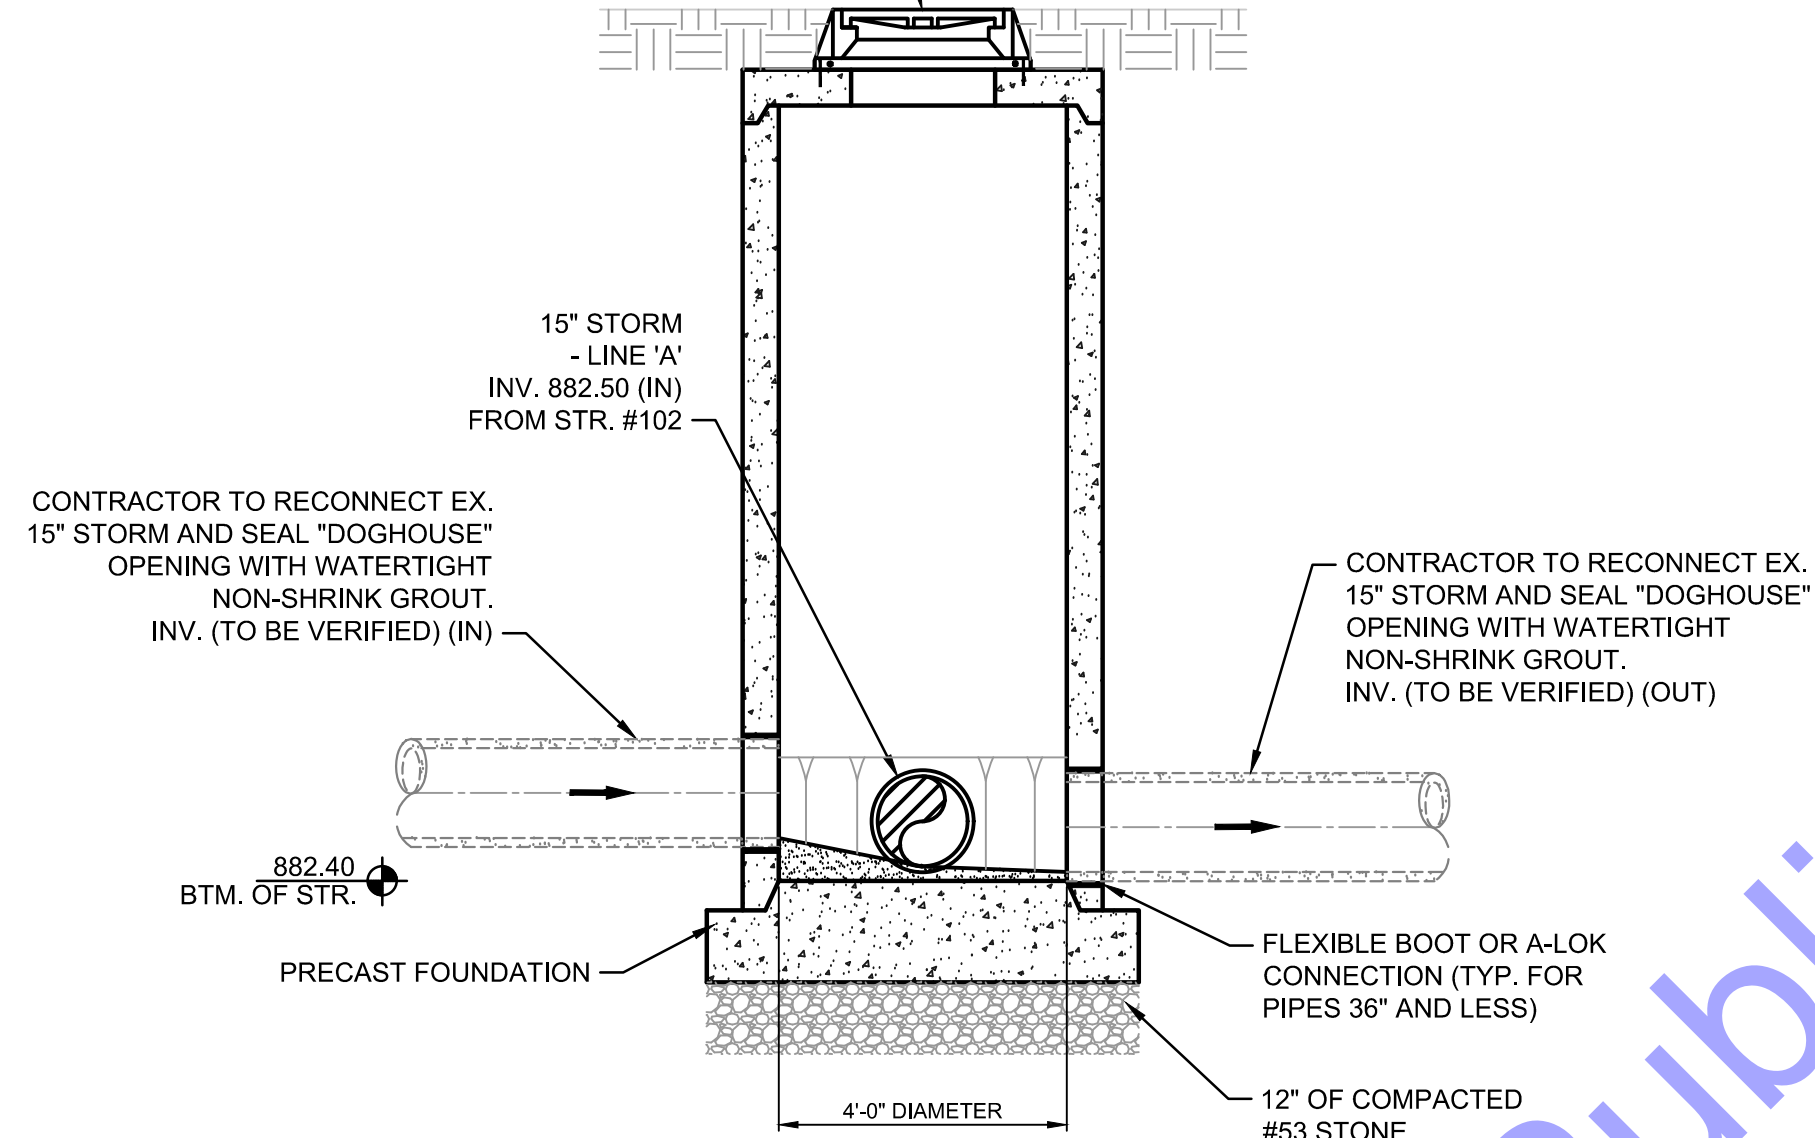SECTION (A)

4' DIAMETER "DOGHOUSE" STRUCTURE #101
SCALE: 3/8"=1'-0"

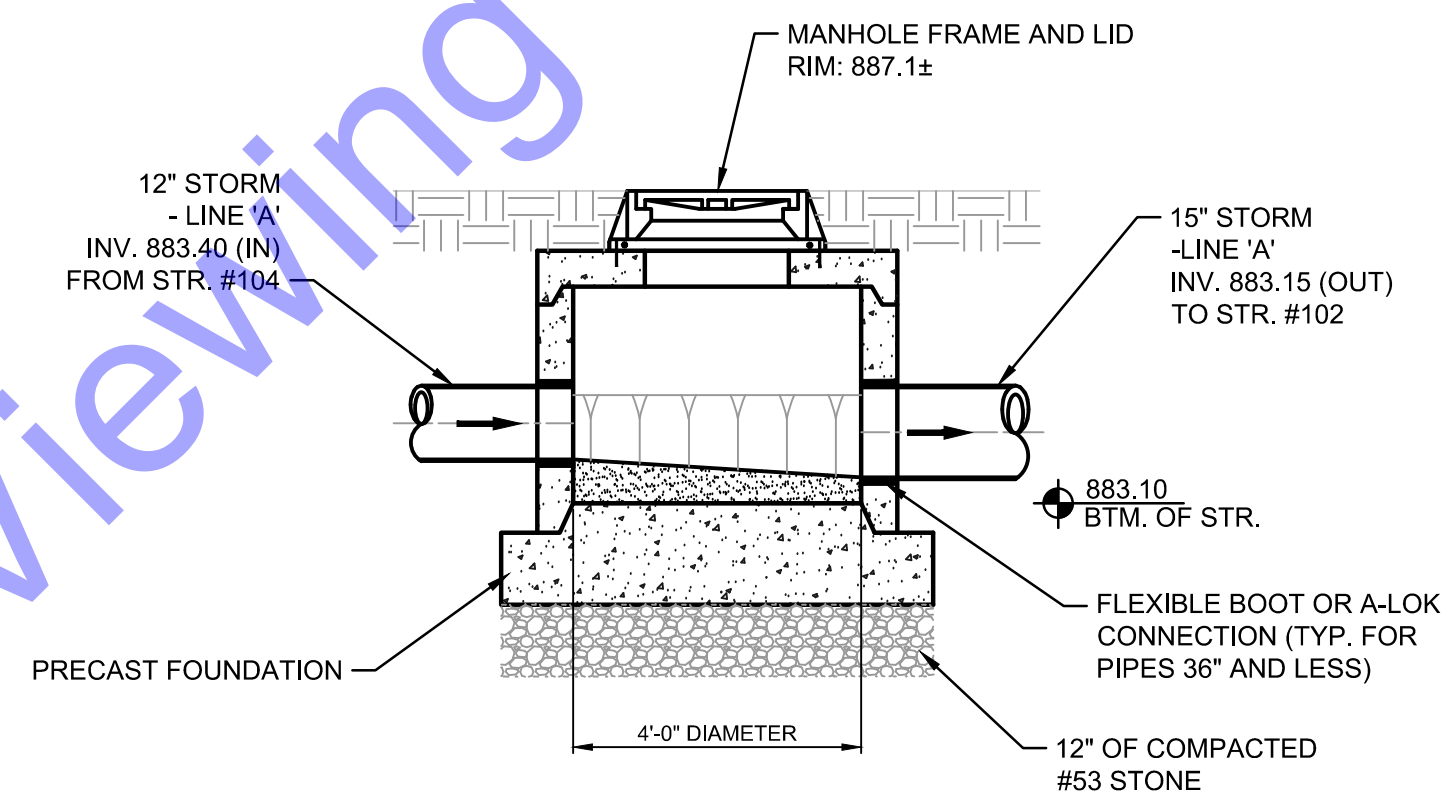SECTION B



4' DIAMETER STRUCTURE #103
SCALE: 3/8"=1'-0"

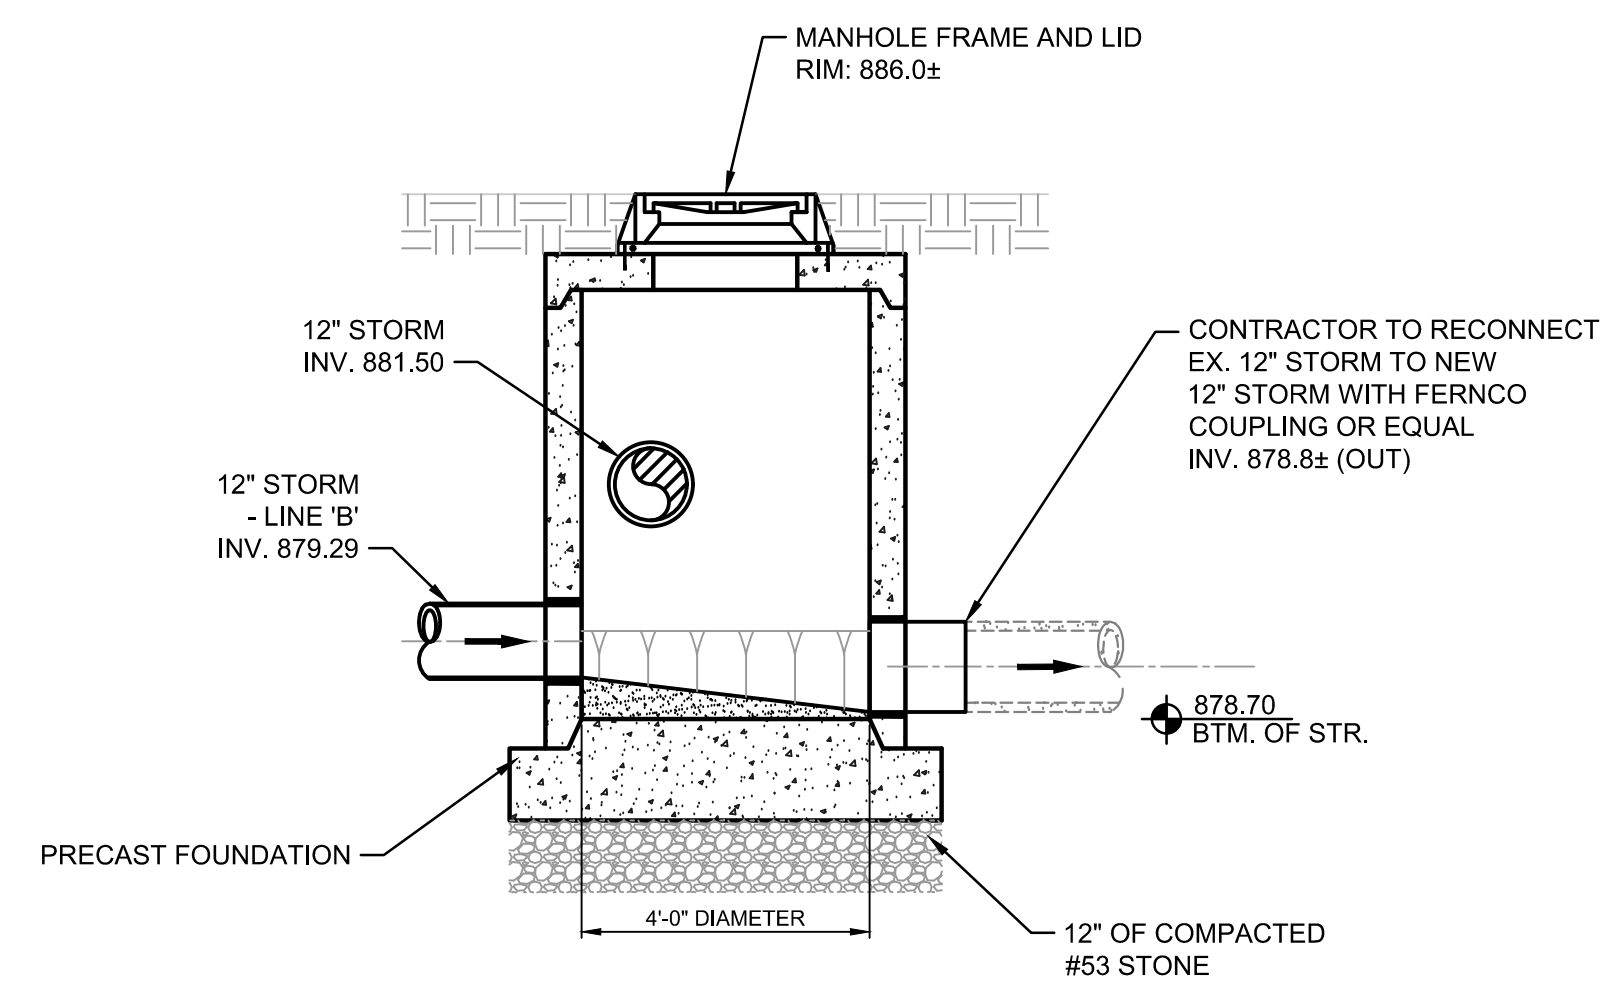

SECTION _____ (C)

4' DIAMETER STRUCTURE #106
SCALE: 3/8"=1'-0"

 
NOTE:
CONTRACTOR TO FIELD VERIFY LOCATION, SIZE, AND DEPTH OF
EXISTING STORM SEWER PRIOR TO ORDERING STRUCTURES.

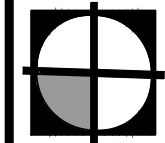

COMMONWEALTHTM
ENGINEERS, INC.
A wealth of resources to master a common goal.
commonwealthengineers.com/

OFFICE LOCATIONS IN:

INDIANAPOLIS, IN. (2)
EVANSVILLE, IN.
FORT WAYNE, IN.
CROWN POINT, IN.
BOWLING GREEN, KY.
SOUTH BEND, IN.

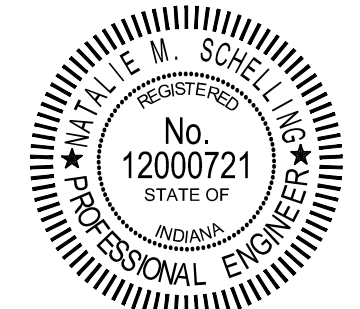

Signature Natalie Schelling Date 12/31/2024

**TOWN OF CLAYPOOL
KOSCIUSKO COUNTY, INDIANA**

**CONTRACT C -
STORM SEWER
IMPROVEMENTS**

© 2024 BY COMMONWEALTH ENGINEERS, INC. ALL RIGHTS RESERVED. REPRODUCTION BY ANY METHOD IN WHOLE OR IN PART WITHOUT PERMISSION IS PROHIBITED



—800-382-5544
(ITS THE LAW)

[illegible]

Designed By: BW	Drawn By: CH	Checked By: NS
--------------------	-----------------	-------------------


Issue Date: 12/2024	Project No: S23130	Scale: AS SHOWN
------------------------	-----------------------	--------------------

STRUCTURE DETAILS

Drawing No:

SS1

 Sheet: 13 OF 21



OFFICE LOCATIONS IN:
INDIANAPOLIS, IN. (2)
EVANSVILLE, IN.
FORT WAYNE, IN.
CROWN POINT, IN.
BOWLING GREEN, KY.
SOUTH BEND, IN.




**CONTRACT C -
STORM SEWER
IMPROVEMENTS**

—800-382-5544
(ITS THE LAW)

Designed By: BW	Drawn By: CH	Checked By: NS
Issue Date: 12/2024	Project No: S23130	Scale: AS SHOWN

Drawing No:

 SS2



(SEE DWG.PP5)




SCALE: 3/8"=1'-0"



(SEE DWG.PP6)



SCALE: 3/8"=1'-0"

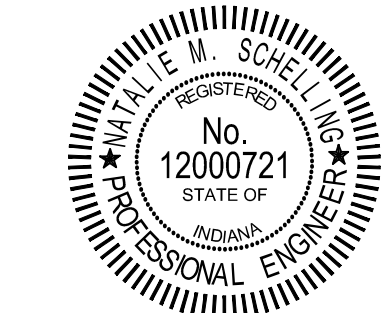

Signature Natasha Adelberg

**TOWN OF CLAYPOOL
KOSCIUSKO COUNTY, INDIANA**

CONTRACT C - STORM SEWER IMPROVEMENTS

© 2024 BY COMMONWEALTH
ENGINEERS, INC. ALL RIGHTS
RESERVED. REPRODUCTION BY
ANY METHOD IN WHOLE OR
IN PART WITHOUT PERMISSION
IS PROHIBITED

Indiana 811
Know what's below.
Call before you dig.
now what's below. 811 before you dig.
1-800-382-5544
(IT'S THE LAW)


[illegible]

STRUCTURE DETAILS

Drawing No:

SS3

Sheet: 15 OF 21

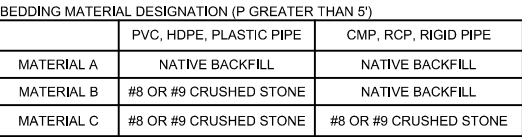

BEDDING MATERIAL DESIGNATION (LESS THAN 5", BUT GREATER THAN 0")		
	PVC, HDPE, PLASTIC PIPE	CMP, RCP, RIGID PIPE
MATERIAL A	NATIVE BACKFILL	NATIVE BACKFILL
MATERIAL B	#8 OR #9 CRUSHED STONE	#8 OR #9 CRUSHED STONE
MATERIAL C	#8 OR #9 CRUSHED STONE	#8 OR #9 CRUSHED STONE

BEDDING MATERIAL DESIGNATION (PIPE UNDER PAVEMENT OR DRIVEWAY)		
	PVC, HDPE, PLASTIC PIPE	CMP, RCP, RIGID PIPE
MATERIAL A	PIPE NOT ALLOWED	#5 OR #9 CRUSHED STONE
MATERIAL B	PIPE NOT ALLOWED	#5 OR #9 CRUSHED STONE
MATERIAL C	PIPE NOT ALLOWED	#5 OR #9 CRUSHED STONE

1. INDOT TYPE 1 PIPE REQUIRED FOR STORM SEWERS/CULVERTS UNDER PAVEMENT
2. INDOT TYPE 2 PIPE REQUIRED FOR STORM SEWERS/CULVERTS OUTSIDE OF PAVEMENT
3. ALL BEDDING SHALL BE INSTALLED IN 6" TO 12" BALANCED LIFTS
4. FOR BACKFILL PURPOSES, PAVED SHOULDERS, CURBS, GUTTERS, AND SIDEWALKS AREA CONSIDERED PAVEMENT
5. FLOWABLE BACKFILL SHALL BE ENCASED BY A MINIMUM OF 2' OF COMPACTED EARTH BACKFILL
6. PLASTIC PIPES FABRICATED ON HYDROSTATIC DESIGN BASIS RATED RESINS CONSIDERED RIGID FOR BACKFILL PURPOSES
7. MANUFACTURER'S SPECIFICATIONS MAY BE ACCEPTED FOR USE WITH PVC, HDPE, AND PLASTIC PIPES AS AN ALTERNATIVE TO THE MATERIALS NOTED HERE (WITH PRIOR APPROVAL OF THE COUNTY SURVEYOR).

NOT TO SCALE



**CONTRACT C -
STORM SEWER
IMPROVEMENTS**

© 2024, BY COMMONWEALTH ENGINEERS, INC. ALL RIGHTS RESERVED. REPRODUCTION BY ANY METHOD IN WHOLE OR IN PART WITHOUT PERMISSION IS PROHIBITED

Indiana 811

 
Know what's below.
Call before you dig.

Know what's below. 811 before you dig.


1-800-382-5544
(IT'S THE LAW)


[illegible]

Drawing No:
MD1



 NEW "DOG-HOUSE" MANHOLE OVER EXISTING STORM DETAIL
NO SCALE




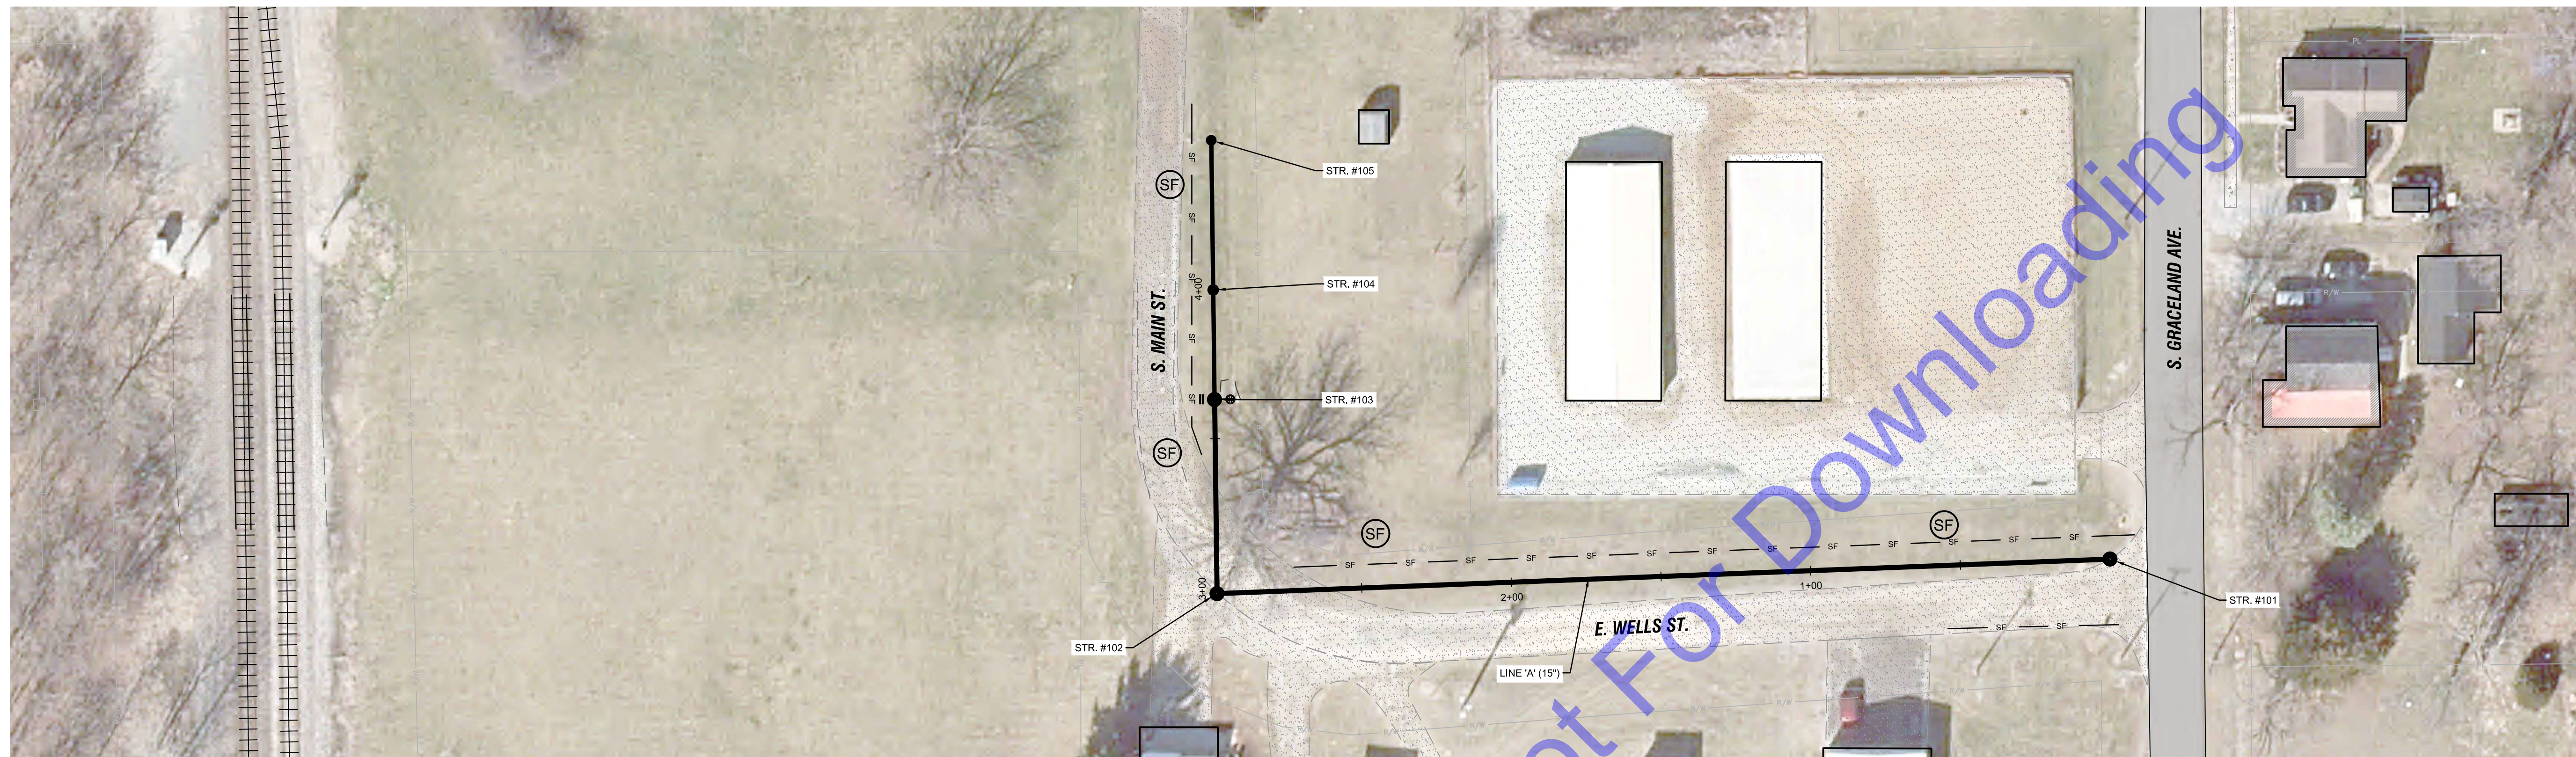

EROSION CONTROL PLAN
LINE 'A'
SCALE: 1"=30'-0"




EROSION CONTROL PLAN
LINE 'B'
SCALE: 1"=30'-0"

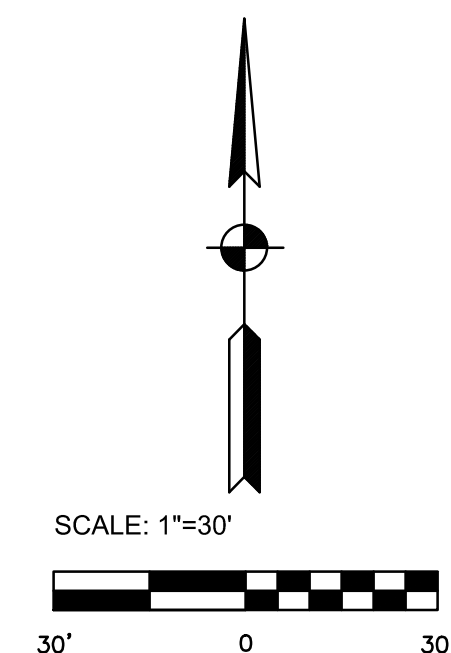


EROSION CONTROL LEGEND

- SF — (SF) SILT FENCE
- (CD) ROCK CHECK DAM
- ⦿ (IP) INLET PROTECTION


[illegible]

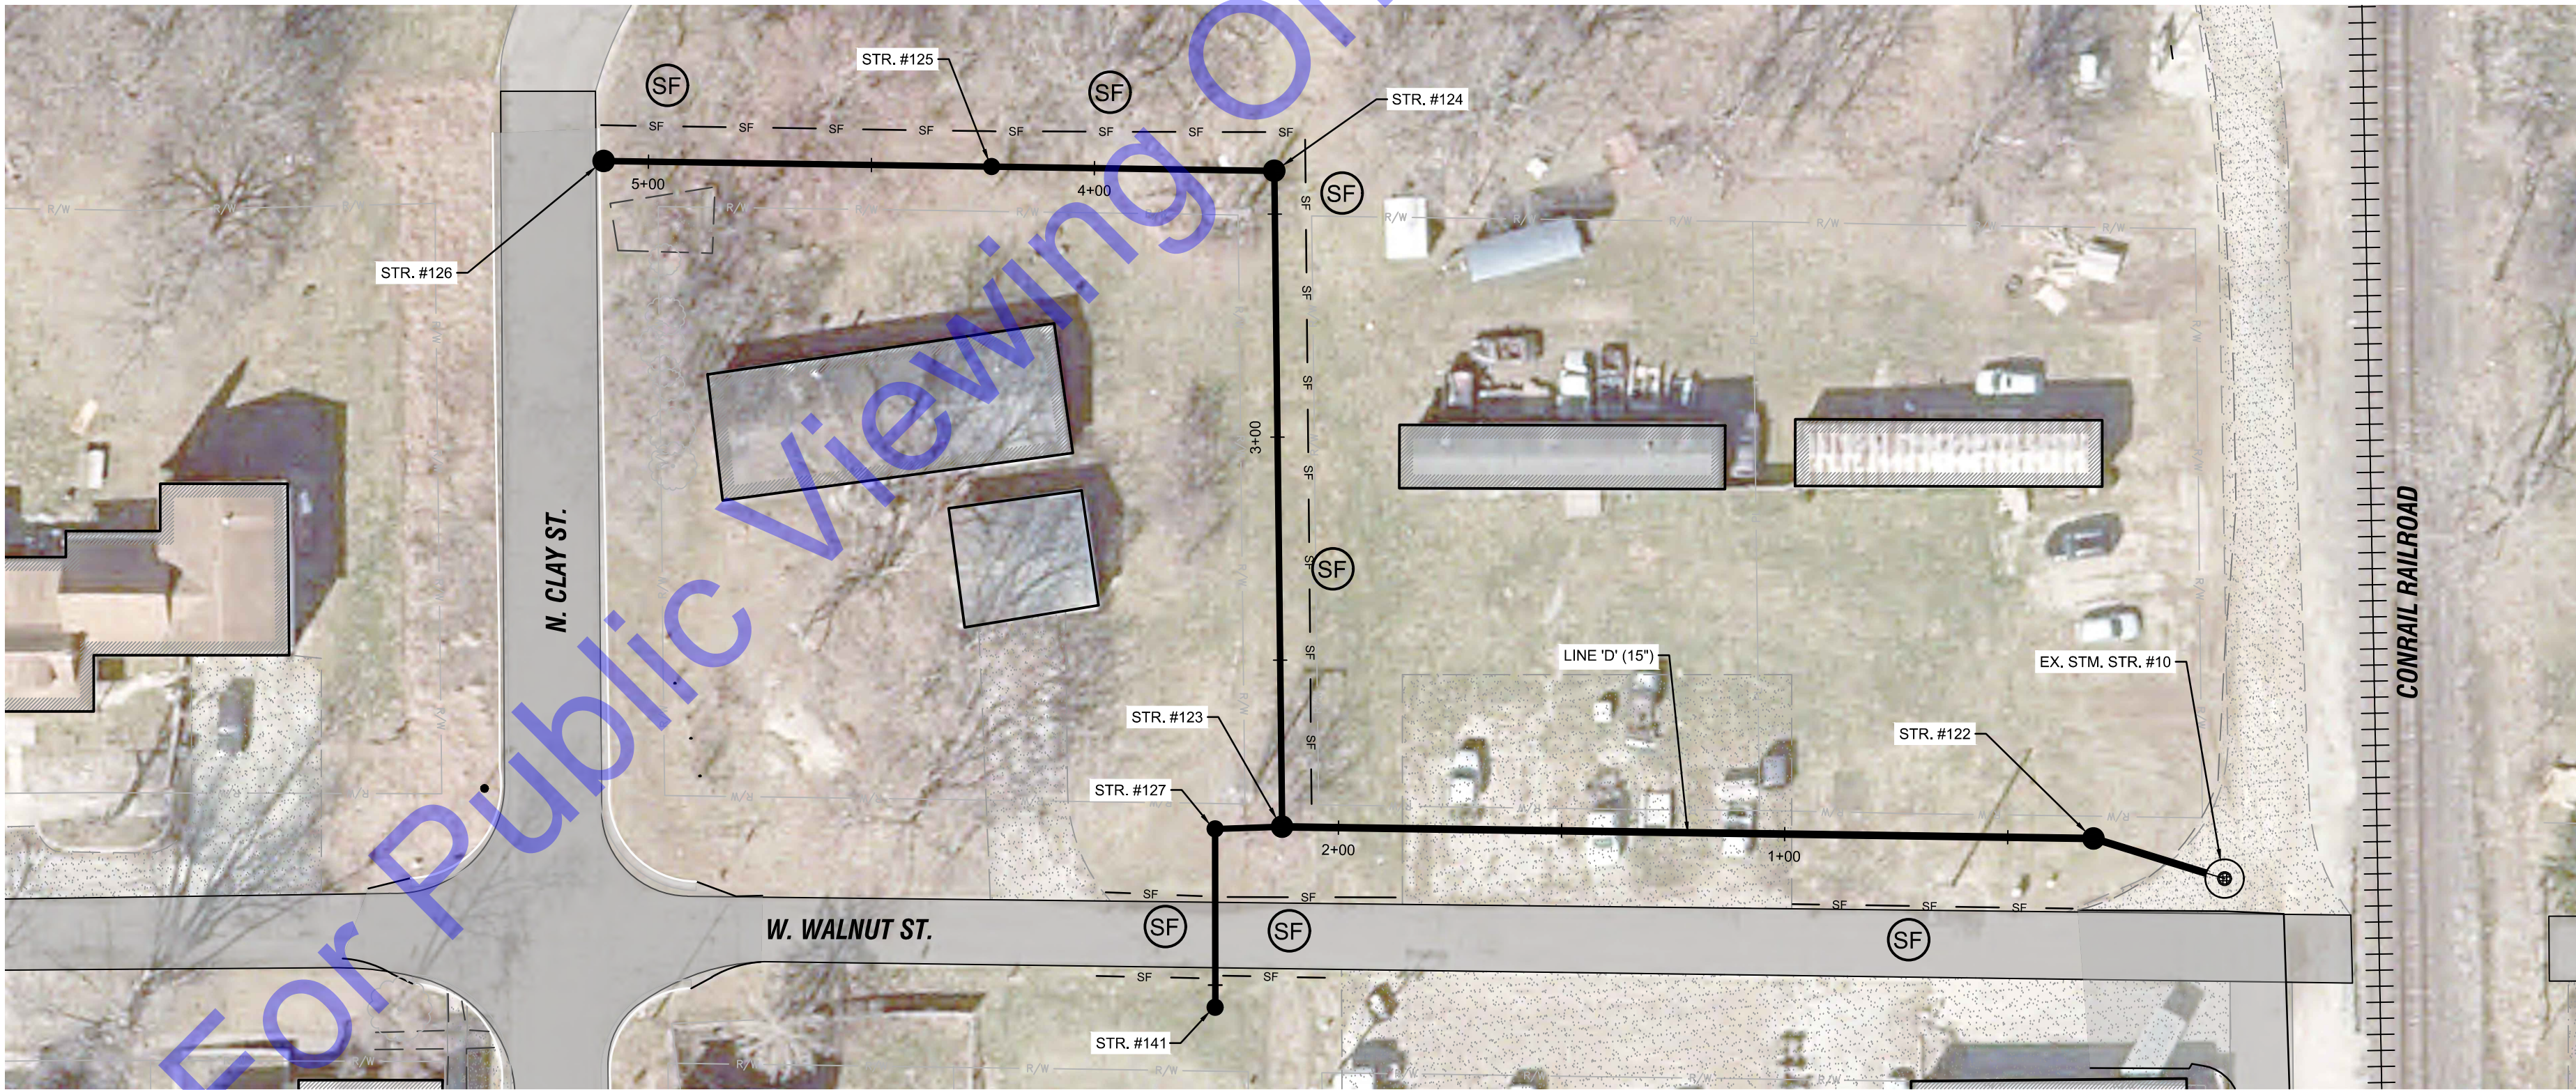


EROSION CONTROL PLAN
LINE 'D'
SCALE: 1"=30'-0"

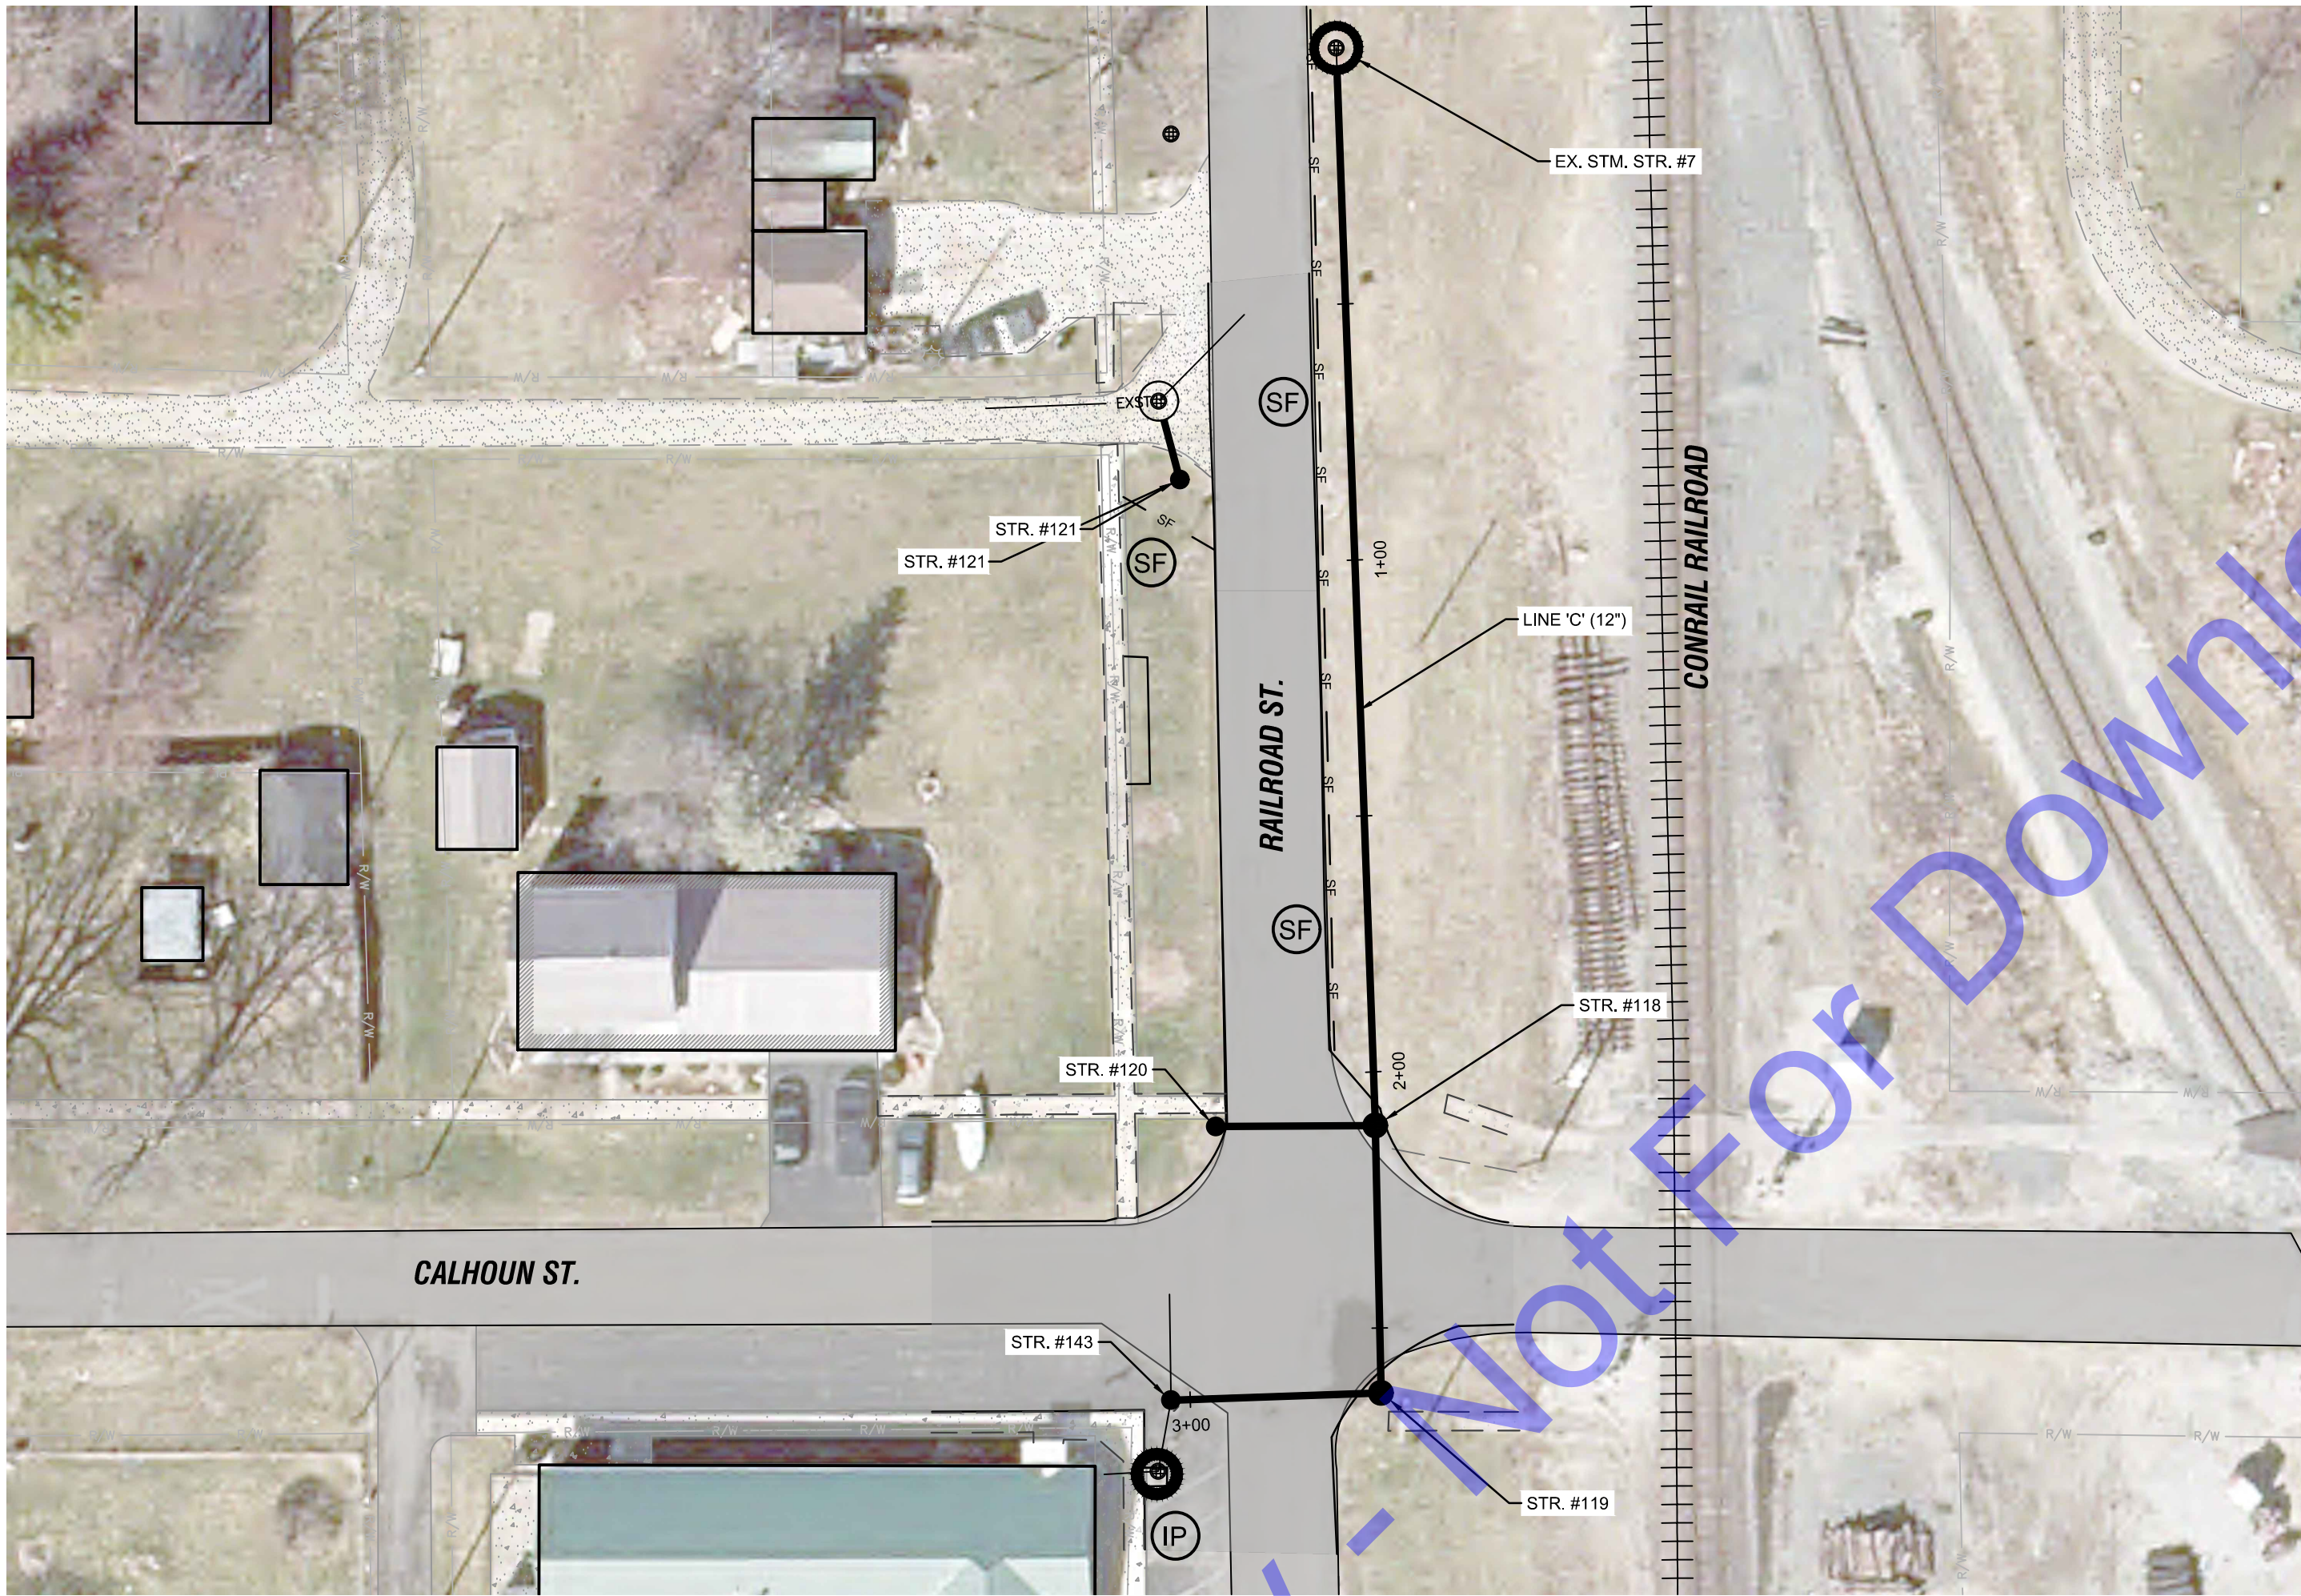


EROSION CONTROL PLAN
LINE 'D'
SCALE: 1"=30'-0"

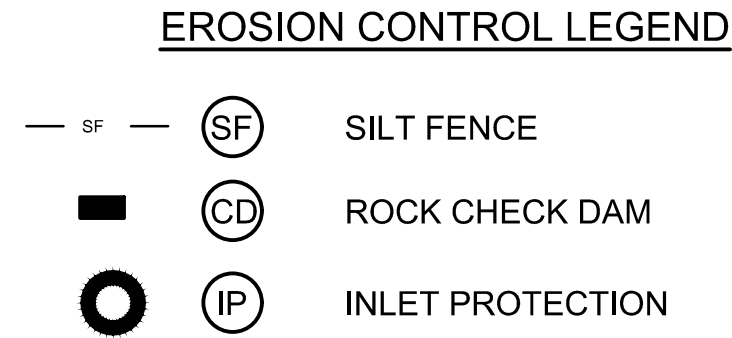
[illegible]

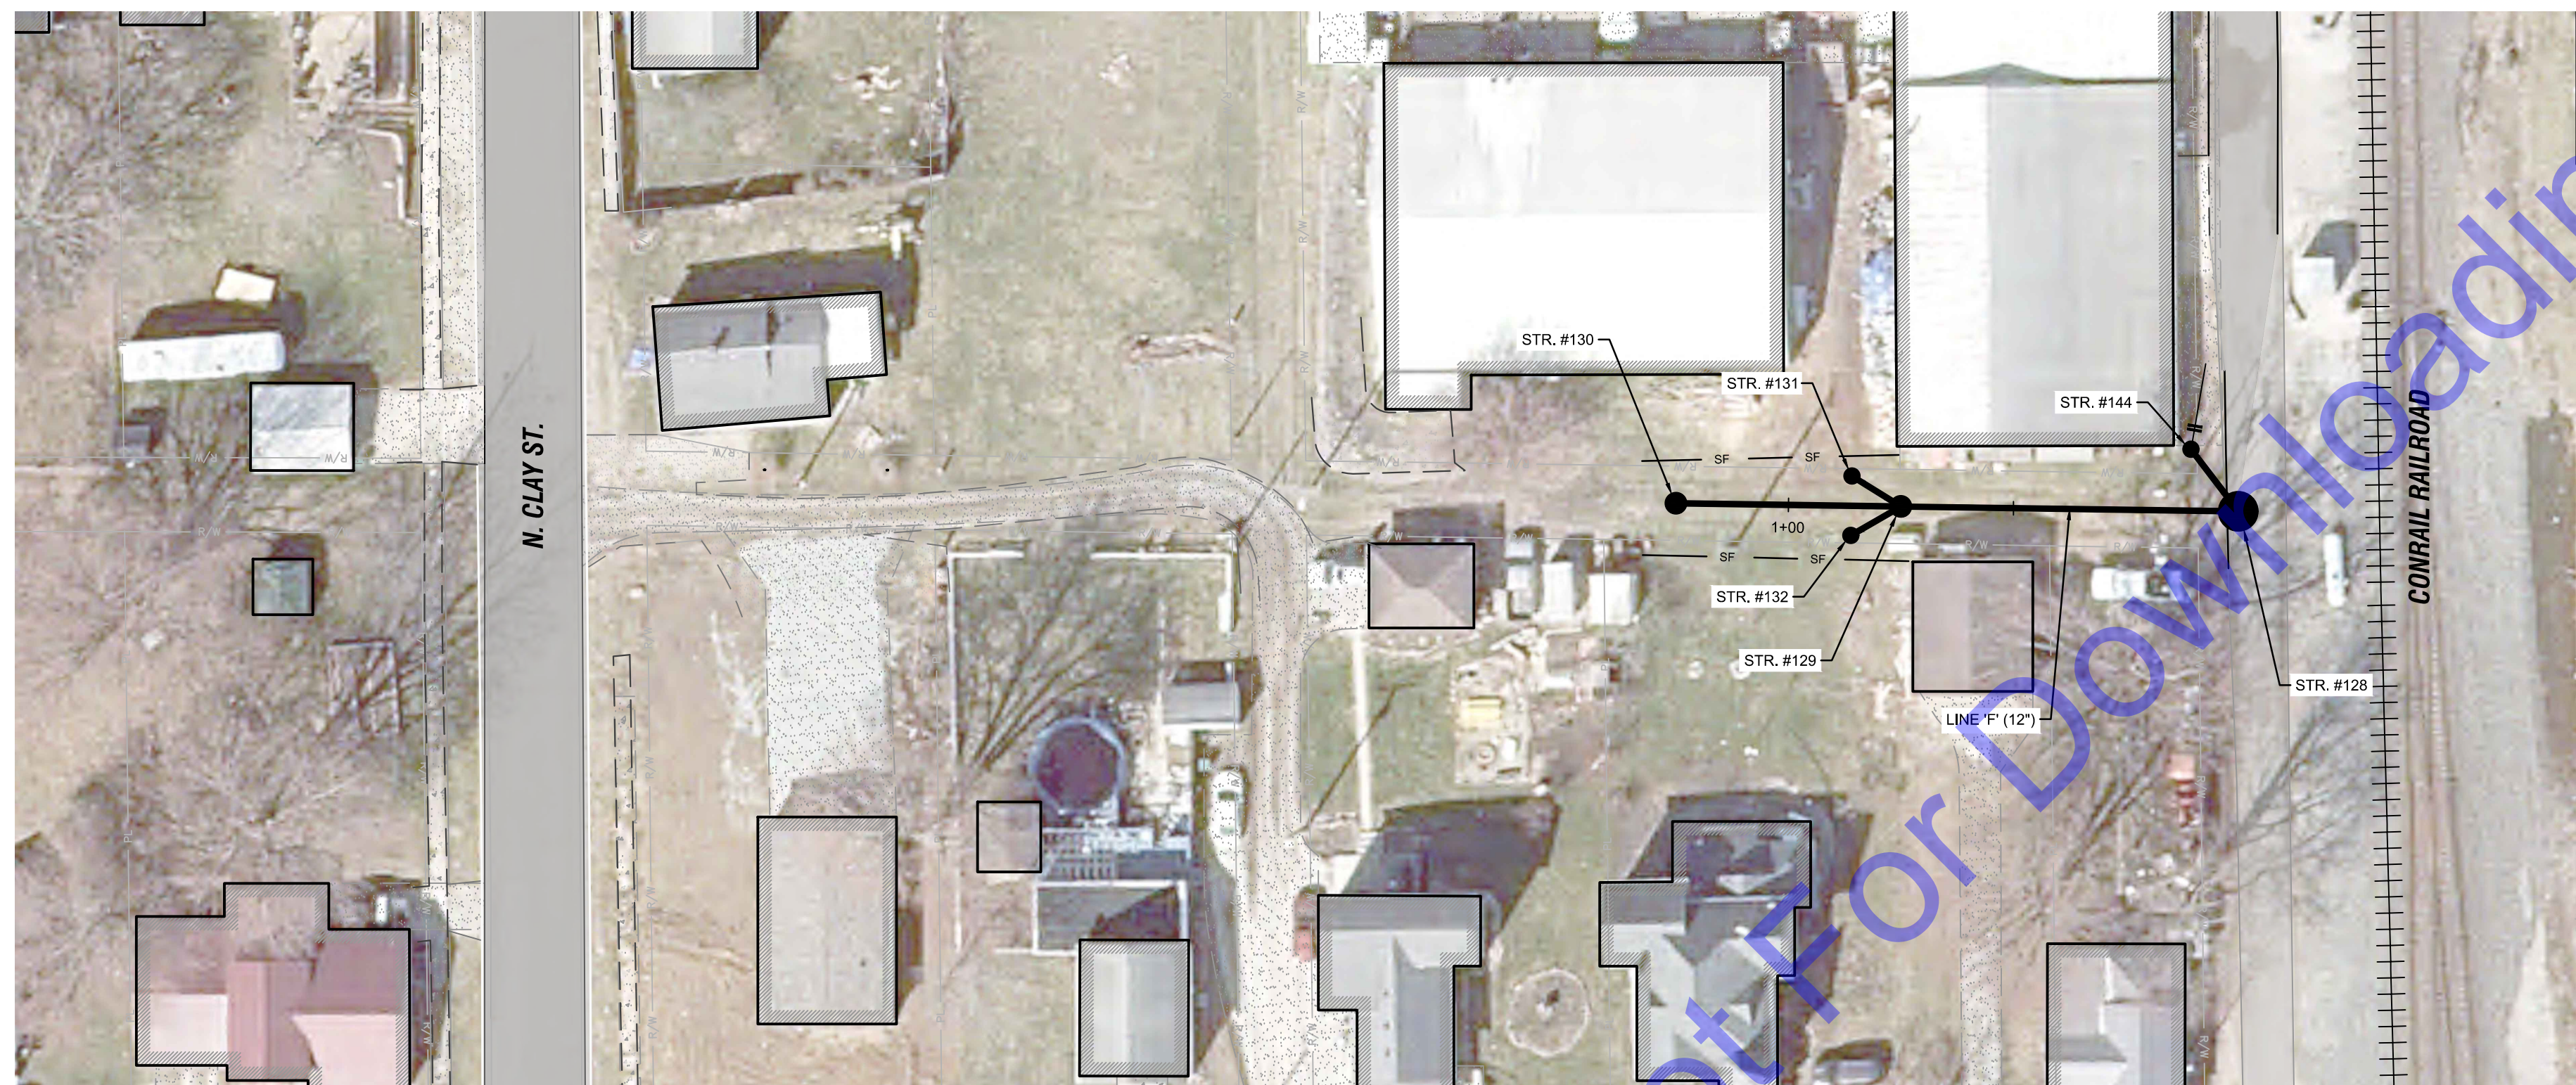

EROSION CONTROL PLAN
LINE 'F'
SCALE: 1"=30'-0"

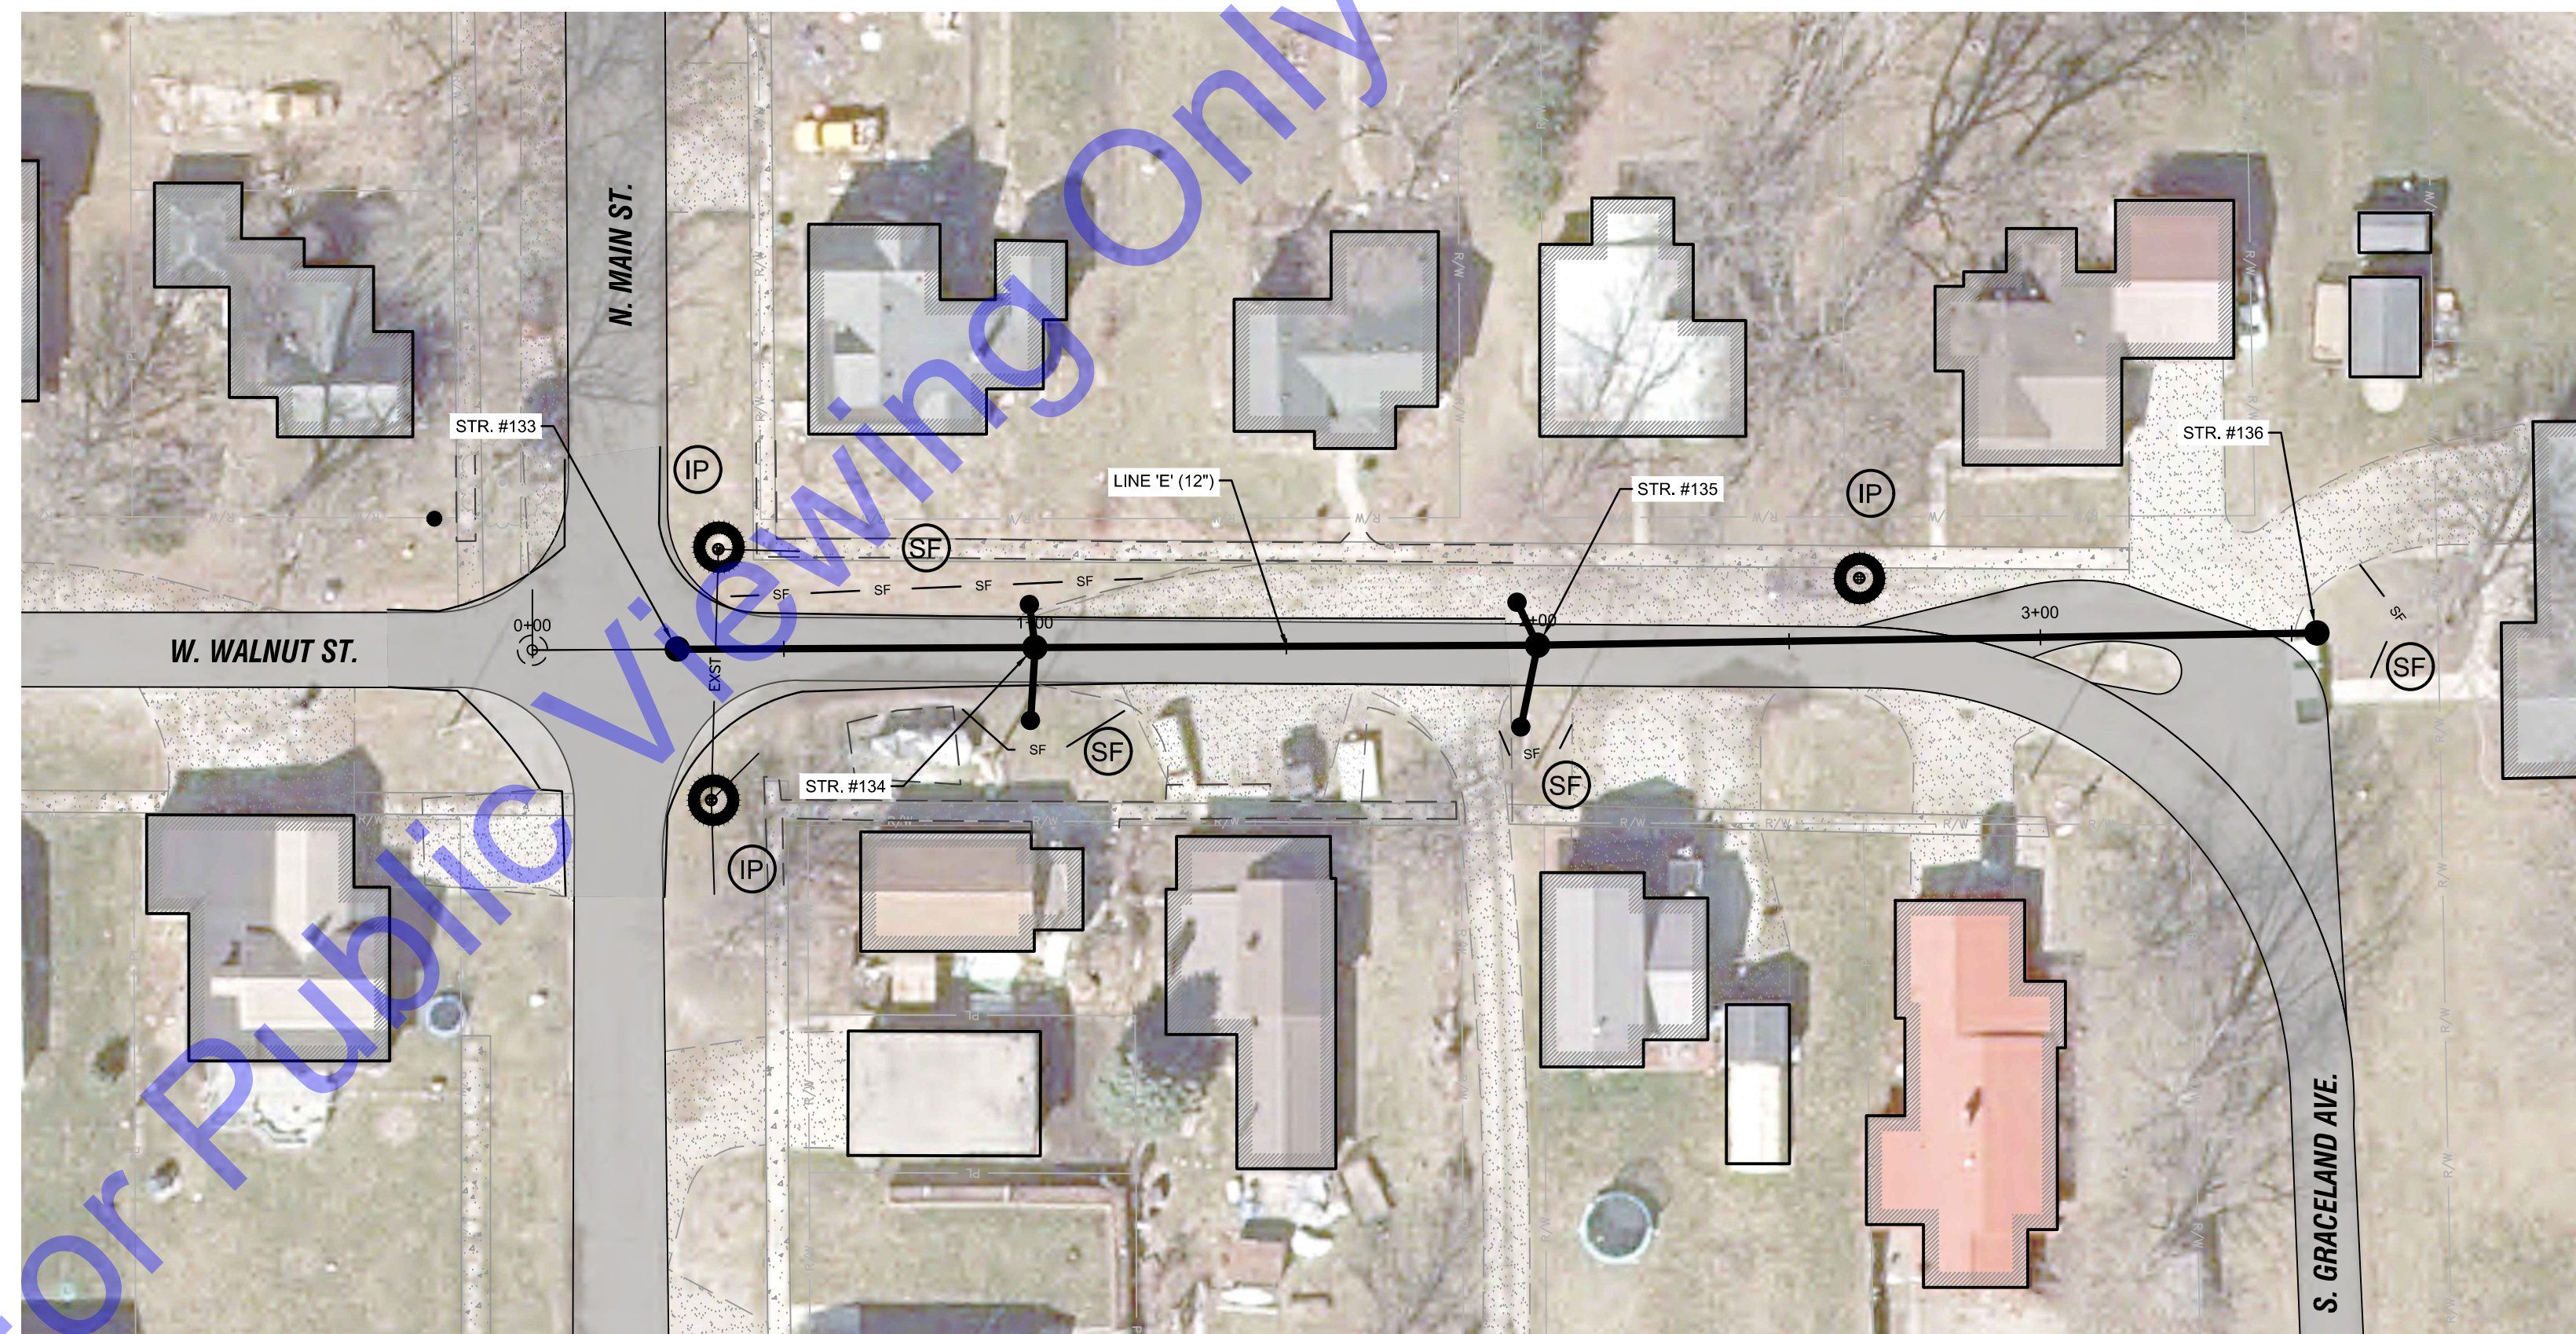


EROSION CONTROL PLAN
LINE 'E'
SCALE: 1"=30'-0"

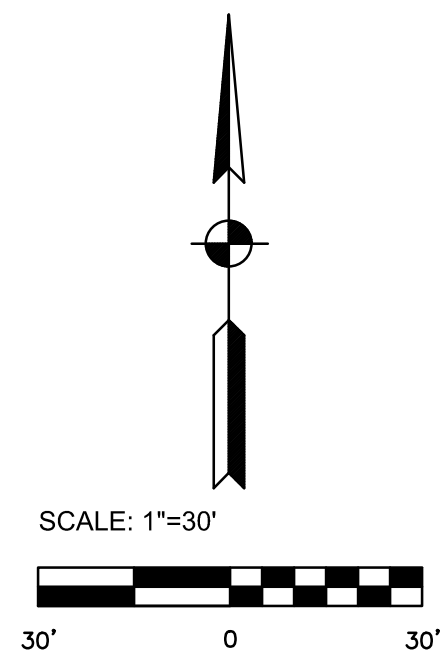

EROSION CONTROL LEGEND

- SF — (SF) SILT FENCE
- (CD) ROCK CHECK DAM
- ⊙ (IP) INLET PROTECTION

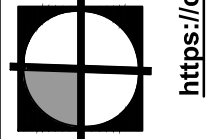

**COMMONWEALTH™
ENGINEERS, INC.**
A wealth of resources to master a common goal.
commonwealthengineers.com/




Signature Natalie Schellhies Date 12/31/2024

**TOWN OF CLAYPOOL
KOSCIUSKO COUNTY, INDIANA**

**CONTRACT C -
STORM SEWER
IMPROVEMENTS**

© 2024 BY COMMONWEALTH ENGINEERS, INC. ALL RIGHTS RESERVED. REPRODUCTION BY ANY METHOD IN WHOLE OR IN PART WITHOUT PERMISSION IS PROHIBITED

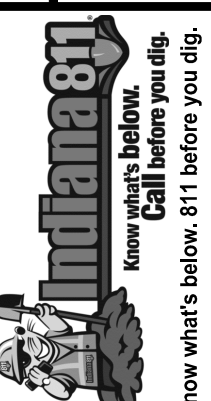

1-800-382-5544
(ITS THE LAW)

[illegible]


Designed By: BW	Drawn By: CH	Checked By: NS
Issue Date: 12/2024	Project No: S23130	Scale: AS SHOWN

EROSION CONTROL


Drawing No:

EC3

Sheet: 20 OF 21

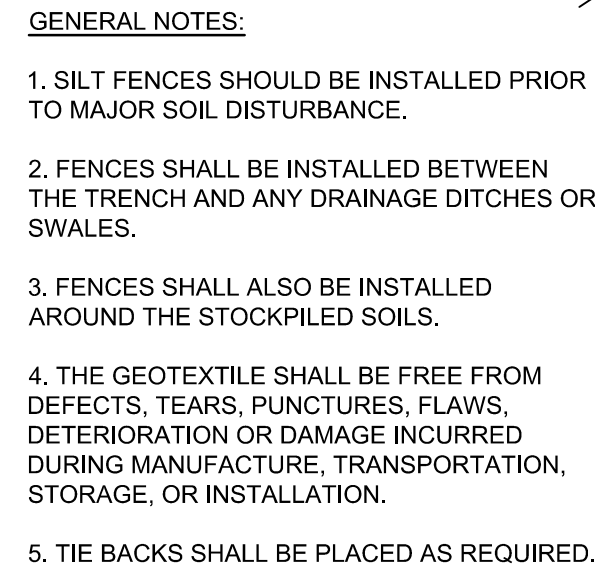

9. A LOG SHALL BE MAINTAINED OF ALL INSPECTIONS (WEEKLY, AND FOLLOWING STORM EVENTS), MAINTENANCE AND REPAIR OF EROSION AND SEDIMENT CONTROL MEASURES. THE LOG SHALL BE MAINTAINED ON SITE AND BE AVAILABLE UPON REQUEST TO THE OWNERS REPRESENTATIVES AND THE OPERATING AUTHORITIES HAVING JURISDICTION OVER THE SITE.

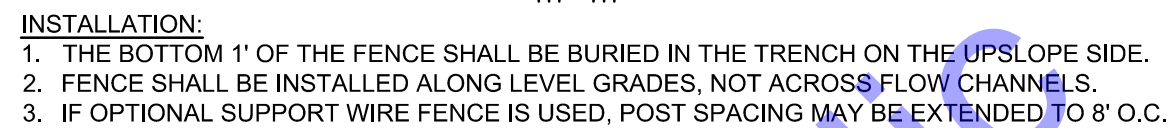

- MAINTENANCE:**
1. INSPECT SILT FENCE PERIODICALLY (WEEKLY) AND AFTER EACH STORM EVENT.
 2. IF FABRIC IS TORN OR DAMAGED OR IN ANY WAY BECOMES INEFFECTIVE, REPLACE THE AFFECTED PORTION IMMEDIATELY.
 3. REMOVE DEPOSITED SEDIMENT WHEN IT REACHES HALF THE HEIGHT OF THE FENCE, OR IT IS CAUSING THE FENCE TO BULGE.
 4. TAKE CARE NOT TO UNDERMINE THE FENCE DURING SEDIMENT REMOVAL.
 5. AFTER THE CONTRIBUTING AREA HAS BEEN STABILIZED, REMOVE THE FENCE AND REMAINING SEDIMENT, BRING THE DISTURBED AREA TO GRADE, AND STABILIZE.



 COMMONWEALTH ENGINEERS, INC. A wealth of resources to make a common good. https://commonwealthengineers.com/ OFFICE LOCATIONS IN: INDIANAPOLIS, IN (2) EVANSVILLE, IN FORT WAYNE, IN CROWN POINT, IN BOWLING GREEN, KY SOUTH BEND, IN		 <i>Natalie Schell</i> Signature _____ Date <u>12/31/2024</u>							
TOWN OF CLAYPOOL KOSCIUSKO COUNTY, INDIANA		CONTRACT C - STORM SEWER IMPROVEMENTS							
© 2024 BY COMMONWEALTH ENGINEERS. ALL RIGHTS RESERVED. REPRODUCTION BY ANY METHOD IN WHOLE OR IN PART WITHOUT PERMISSION IS PROHIBITED.  Know what's below. Call before you dig. 1-800-382-5544 (ITS THE LAW)									
No.	Submitted / Revision	By	Date	Designed By:		Drawn By:		Checked By:	
				BW		CH		NS	
				Issue Date:		Project No:		Scale:	
				12/2024		S23130		AS SHOWN	
EROSION CONTROL DETAILS									
Drawing No: EC4									
Sheet: 21 OF 21									